

ENGINEER'S STATEMENT

PROJECT SCOPE OF WORK

DRAWING AND SPECIFICATIONS

PIPING NOTES

HVAC SHEET INDEX		
Sheet Number	Sheet Name	Sheet Issue Date
M0.0	MECHANICAL COVER SHEET	16SEP24
M1.1	EXISTING MECHANICAL FLOOR PLAN - LEVEL 1	16SEP24
M1.2	NEW CONSTRUCTION MECHANICAL FLOOR PLAN - LEVEL 1	16SEP24
M5.1	SCHEDULES	16SEP24
M5.2	SCHEDULES	16SEP24
M7.1A	VRF UNITS 1 AND 2	16SEP24
M7.1B	VRF UNITS 3 AND 4	16SEP24
M7.2	VRF CONTROLS	16SEP24
M7.3	VRF CONTROLS POINTS	16SEP24
M7.5	SEQUENCE OF OPERATIONS	16SEP24

GENERAL NOTES

DEMO NOTES

HVAC/ SHEETMETAL NOTES

- A. ENGINEER OF RECORD (EOR) ANDRE GILL ENGINEERING, LLC (AGE) WAS HIRED BY NBNERR TO PROVIDE AND UPGRADED HVAC SYSTEM AND SUPPORT ELECTRIFICATION INITIATIVES. ALSO, SELECT AND SPECIFY EQUIPMENT TO BE INSTALLED BY THE SUCCESSFUL CONTRACTOR FOR WORK DESCRIBED IN THE PROJECT SCOPE OF WORK. THE SELECTED EQUIPMENT REQUIRED AND UPGRADE TO THE MAIN DISTRIBUTION PANEL AS SHOWN ON THE ELECTRICAL DRAWINGS.
- B. THE PREVIOUS FURNACES ARE TO BE REMOVED AND REPLACED WITH MITSUBISHI/ TRANE MULTI POSITION AIR HANDLERS AS SHOWN ON THE SCHEDULE UTILIZING THE EXISTING DUCTWORK. FRESH AIR/ VENTILATION AIR WILL BE PROVIDED VIA TWO CEILING MOUNTED DUCTED MITSUBISHI/ TRANE FRESH AIR UNITS THAT WILL BE RUN WITH NEW SEPARATE DUCTWORK AS SHOWN ON THE PLANS. ALL SELECTED EQUIPMENT SHALL BE SUBMITTED FOR FINAL APPROVAL TO ENSURE ALL CODE REQUIREMENTS ARE MET. THE CONTRACTOR SHALL ENSURE PRIOR TO BID SUBMISSION THAT EQUIPMENT BEING SELECTED MEETS ALL MINIMUM REQUIREMENTS OF THE RHODE ISLAND STATE BUILDING CODE AND ALL OTHER APPLICABLE CODES.
- D. TRANE/MITSUBISHI IS THE BASIS OF DESIGN FOR MECHANICAL EQUIPMENT AND SHALL NOT BE SUBSTITUTED WITHOUT APPROVAL OF THE EOR AND SUBSEQUENTLY NBNERR TO ENSURE COMPLIANCE AND CONFORMANCE WITH THE ELECTRICAL DESIGN. CONTRACTOR SHALL PROVIDE DATA SHOWING AT A MINIMUM EQUIVALENCE TO BASIS OF DESIGN EQUIPMENT. EQUIVALENCE SHALL BE IN ALL MAJOR ASPECT OF OPERATIONAL PERFORMANCE. ALTERNATE MANUFACTURERS MAY BE SUBMITTED FOR APPROVAL AS REQUIRED TO ENSURE COST TO THE OWNER IS REDUCED WHILE MEETING THE MINIMUM CODE COMPLIANCE OF THE AHI. HOWEVER THE CONTRACTOR SHALL SUBMIT DETAILED INFORMATION HIGHLIGHTING EQUIVALENCE.
- SCOPE OF WORK**
- A. ALL CONTRACTORS SHALL FOLLOW THE CURRENT ENFORCED **RHODE ISLAND STATE BUILDING CODES** AS A MINIMUM, HOWEVER SECTIONS OF THESE DOCUMENTS REFLECT CURRENT VERSION OF ICC INTERNATIONAL CODES WHERE THEY SUPERSEDE RISBC. ALL CONTRACTORS SHALL FOLLOW ALL LOCAL REQUIREMENTS BY AUTHORITIES HAVING JURISDICTION.
- B. CONTRACTORS SHALL INSTALL ALL EQUIPMENT FOLLOWING ASHRAE, ASME, ASTM, NFPA AND NEC STANDARDS.
- C. CONTRACTORS SHALL PROVIDE ALL LABOR, MATERIALS, EQUIPMENT AND SERVICES AS SHOWN AND/OR IMPLIED ON DRAWINGS AND SPECIFICATIONS FOR A COMPLETE AND PROPER INSTALLATION. THE DRAWINGS ARE NOT ALL INCLUSIVE AND THE CONTRACTOR IS RESPONSIBLE FOR A COMPLETE INSTALLATION. THE DRAWINGS SHOW MAJOR COMPONENTS AND ALL QUALIFIED CONTRACTORS SHALL HAVE SUFFICIENT EXPERIENCE IN PERFORMANCE OF THIS INSTALLATION.
- D. CONTRACTORS SHALL FURNISH AND INSTALL, PURGE, CHARGE, TEST AND OPERATE ALL EQUIPMENT, ACCESS DOORS, CAULKING, SLEEVES, FLASHING, FLEXIBLE CONNECTIONS, INSERTS, DEVICES, HANGERS, SUPPORTS, BRACING, FASTENERS, MISCELLANEOUS HARDWARE AND INSULATION.
- E. CONTRACTOR SHALL OBTAIN AND PAY FOR PERMITS, INSPECTIONS AND TESTS REQUIRED BY GOVERNING AUTHORITIES HAVING JURISDICTION.
- F. PROVIDED EQUIPMENT AND/OR EQUIPMENT COMPONENTS WITH UL LABELS TO COMPLY WITH THE NATIONAL ELECTRIC CODE.
- G. MAINTAIN COMPLIANCE WITH OSHA THROUGHOUT THE CONSTRUCTION PHASE AND WITH COMPLETED WORK.
- H. PROVIDE ALL LABOR, MATERIALS, PLANT EQUIPMENT AND SERVICES NECESSARY AND REQUIRED TO COMPLETE MEP WORK AS SHOWN ON AND/OR REASONABLY IMPLIED BY THE DRAWINGS AND SPECIFICATIONS.
- I. THE FOLLOWING ARE THE GENERAL CLASSIFICATIONS OF WORK INCLUDED IN, BUT NOT LIMITED TO THIS SECTION.
- J. RECEIVING, RIGGING, SETTING AND INSTALLATION OF THE PURCHASED EQUIPMENT.
- K. PROVIDING OF SHOP DRAWINGS FOR APPROVAL, WITHIN ALLOWANCE OF ACCEPTANCE AND INSTALLATION TO NOT HINDER CONSTRUCTION SCHEDULE.
- L. PURCHASE INSTALL, ELECTRICAL AND PIPING OF NEW EQUIPMENT AS SCHEDULED.
- M. DEMOLITION AND MAKE SAFE EXISTING PIPING, DUCTWORK AND ASSOCIATED HANGERS AS INDICATED ON DRAWINGS.
- N. DEMOLITION AND MAKE SAFE EXISTING ELECTRICAL AND CONDUIT AS REQUIRED.
- O. LOW PRESSURE COMPRESSED AIR PIPING, VALVES, FITTINGS, LABELING, TAGGING, ETC.
- P. STEAM AND CONDENSATE PIPING, VALVES, FITTINGS, LABELING, TAGGING, ETC.
- Q. PIPING SUPPORTS INSIDE AND OUTSIDE.
- R. TIE-IN OF FIRE ALARMING DEVICES TO EXISTING SYSTEM.
- S. CONTROL WIRING TO EQUIPMENT AND DEVICES.
- T. WORK PERFORMED DURING SUMMER MONTHS SHALL MAINTAIN HUMIDITY IN ADDITION TO TEMPERATURES.
- U. CUTTING AND PATCHING FOR ALL MECHANICAL WORK.
- V. START-UP OPERATIONS.
- W. CLEAN UP.
- X. COORDINATION AND COOPERATION WITH CONTRACTORS AND SUPPLIERS FOR OTHER SECTIONS AND WITH THE OWNER.
- Y. AS-BUILT DRAWINGS.
- Z. WARRANTY AND GUARANTEE.
- AA. ELECTRICAL POWER WIRING OF NEW EQUIPMENT.
- AB. CONCRETE PADS AS REQUIRED.

- A. REMOVE ABANDONED HVAC EQUIPMENT, MATERIALS, DUCTWORK AND COMPONENTS:
- a. ENSURE THIS IS EITHER ABANDONED IN PLACE OR NO LONGER REQUIRED.
- B. INSTALL NEW EQUIPMENT AND ACCESSORIES TO PROVIDE A COMPLETE INSTALLATION THAT COVERS THE INTENT OF THE DRAWINGS.
- C. INSTALL NEW AND/OR MODIFY DUCTWORK AS APPROPRIATE TO COMPLETE PROJECT.
- D. PROVIDE ALL MECHANICAL, ELECTRICAL, CONTROL WIRING AND PLUMBING FOR NEW EQUIPMENT.

- A. THERE SHALL BE NO SERVICE INTERRUPTION WITHOUT PRIOR APPROVAL.
- B. PROVIDE ALL MATERIALS AND EQUIPMENT AND PERFORM ALL LABOR REQUIRED TO INSTALL COMPLETE AND OPERABLE MECHANICAL SYSTEMS AS INDICATED ON THE DRAWINGS, AS SPECIFIED AND AS REQUIRED BY CODE.
- C. CONTRACT DOCUMENT DRAWINGS FOR MECHANICAL WORK (HVAC, PLUMBING, ELECTRICAL AND FIRE PROTECTION) ARE DIAGRAMMATIC AND ARE INTENDED TO CONVEY SCOPE AND GENERAL ARRANGEMENT ONLY.
- D. INSTALL ALL MECHANICAL EQUIPMENT AND APPURTENANCES IN ACCORDANCE WITH MANUFACTURERS' RECOMMENDATIONS, CONTRACT DOCUMENTS, AND APPLICABLE CODES AND REGULATIONS.
- E. ALL PIPING ON THIS PLAN SHALL BE CONCEALED UNLESS OTHERWISE NOTED.
- F. REPAIR PAVING/FLOOR AFTER INSTALLATION AND INSPECTION OF UTILITIES INSTALLED. PAINT FLOOR TO MATCH PREVIOUS OR MATCH AND COMPLY WITH ARCHITECTURAL DRAWINGS.
- G. CONTRACTOR TO RECONNECT EXISTING ELECTRICAL GROUNDING/BONDING TO COLD WATER PIPING SYSTEM (AS APPLICABLE).
- H. PROVIDE VIBRATION ISOLATION FOR ALL MECHANICAL EQUIPMENT TO PREVENT TRANSMISSION OF VIBRATION TO BUILDING STRUCTURE.
- I. PROVIDE VIBRATION ISOLATORS FOR ALL PIPING SUPPORTS CONNECTED TO AND WITHIN 50 FEET OF ISOLATED EQUIPMENT (EXCEPT AT BASE ELBOW SUPPORTS AND ANCHOR POINTS) THROUGHOUT MECHANICAL EQUIPMENT ROOMS. DO THE SAME FOR SUPPORTS OF STEAM MAINS WITHIN 50 FEET OF BOILER OR PRESSURE REDUCING VALVES.
- J. PROVIDE VIBRATION ISOLATORS FOR ALL PIPING SUPPORTS OF STEAM MAINS WITHIN 50 FEET OF BOILERS AND PRESSURE REDUCING VALVES.
- K. THE LOCATION OF EXISTING UNDERGROUND/UNDERSLAB UTILITIES IS SHOWN IN AN APPROXIMATE WAY ONLY. THE CONTRACTOR SHALL DETERMINE THE EXACT LOCATION OF ALL EXISTING UTILITIES BEFORE COMMENCING WORK. THE CONTRACTOR SHALL PAY FOR AND REPAIR ALL DAMAGES CAUSED BY FAILURE TO EXACTLY LOCATE AND PRESERVE ANY AND ALL UNDERGROUND UTILITIES UNLESS OTHERWISE INDICATED.
- L. COORDINATE CONSTRUCTION OF ALL MECHANICAL WORK WITH ARCHITECTURAL, STRUCTURAL, CIVIL, ELECTRICAL WORK, ETC., SHOWN ON OTHER CONTRACT DOCUMENT DRAWINGS.
- M. MAINTAIN A MINIMUM OF 6'-8" CLEARANCE TO UNDERSIDE OF PIPES, DUCTS, CONDUITS, SUSPENDED EQUIPMENT, ETC., THROUGHOUT ACCESS ROUTES IN MECHANICAL ROOMS.
- N. ALL TESTS SHALL BE COMPLETED BEFORE ANY MECHANICAL EQUIPMENT OR PIPING INSULATION IS APPLIED.
- O. LOCATE ALL TEMPERATURE, PRESSURE, AND FLOW MEASURING DEVICES IN ACCESSIBLE LOCATIONS WITH STRAIGHT SECTION OF PIPE OR DUCT UP- AND DOWNSTREAM AS RECOMMENDED BY THE MANUFACTURER FOR GOOD ACCURACY. PROVIDE ACCESS PANELS WHERE REQUIRED.
- P. TESTING, ADJUSTING, AND BALANCING AGENCY SHALL BE A MEMBER OF THE ASSOCIATED AIR BALANCE COUNCIL (AABC) OR THE NATIONAL ENVIRONMENTAL BALANCING BUREAU (NEBB). TESTING, ADJUSTING, AND BALANCING SHALL BE PERFORMED IN ACCORDANCE WITH THE AABC STANDARDS.
- Q. WHERE TWO OR MORE ITEMS OF THE SAME TYPE OF EQUIPMENT ARE REQUIRED, THE PRODUCT OF ONE MANUFACTURER SHALL BE USED.
- R. REINFORCEMENT, DETAILING, AND PLACEMENT OF CONCRETE SHALL CONFORM TO ASTM 315 AND ACI 318. CONCRETE SHALL CONFORM TO ASTM C94. CONCRETE WORK SHALL CONFORM TO ACI 318, PART ENTITLED "CONSTRUCTION REQUIREMENTS." COMPRESSIVE STRENGTH IN 28 DAYS SHALL BE 3,000 PSI. TOTAL AIR CONTENT OF EXTERIOR CONCRETE SHALL BE BETWEEN 5 AND 7 PERCENT BY VOLUME. SLUMP SHALL BE BETWEEN 3 AND 4 INCHES. CONCRETE SHALL BE CURED FOR 7 DAYS AFTER PLACEMENT.
- S. COORDINATE ALL EQUIPMENT CONNECTIONS WITH MANUFACTURERS' CERTIFIED DRAWINGS. COORDINATE AND PROVIDE ALL DUCT AND PIPING TRANSITIONS REQUIRED FOR FINAL EQUIPMENT CONNECTIONS TO FURNISHED EQUIPMENT. FIELD VERIFY AND COORDINATE ALL DUCT AND PIPING DIMENSIONS BEFORE FABRICATION.
- T. ALL CONTROL WIRE AND CONDUIT SHALL COMPLY WITH THE NATIONAL ELECTRIC CODE AND DIVISION 16 OF THE SPECIFICATION.
- U. CONCRETE HOUSEKEEPING PADS TO SUIT MECHANICAL EQUIPMENT SHALL BE SIZED AND LOCATED BY THE MECHANICAL CONTRACTOR. MINIMUM CONCRETE PAD THICKNESS SHALL BE 6 INCHES. PAD SHALL EXTEND BEYOND THE EQUIPMENT A MINIMUM OF 6 INCHES ON EACH SIDE. CONCRETE HOUSEKEEPING PADS SHALL BE PROVIDED BY THE GENERAL CONTRACTOR. IT SHALL BE THE RESPONSIBILITY OF THE MECHANICAL CONTRACTOR TO COORDINATE SIZE AND LOCATION OF CONCRETE HOUSEKEEPING PADS WITH GENERAL CONTRACTOR.
- V. ALL MECHANICAL ROOM DOORS SHALL BE A MINIMUM OF 4'-0" WIDE.
- W. WHERE BEAMS ARE INDICATED TO BE PENETRATED WITH DUCTWORK OR PIPING, COORDINATE DUCTWORK AND PIPING LAYOUT WITH BEAM OPENING SIZE AND OPENING LOCATIONS. COORDINATION SHALL BE DONE PRIOR TO FABRICATION OF DUCTWORK, CUTTING OF PIPING, OR FABRICATION OF BEAMS.
- X. WHEN MECHANICAL WORK (HVAC, PLUMBING, SHEET METAL, FIRE PROTECTION, ETC.) IS SUBCONTRACTED, IT SHALL BE THE MECHANICAL CONTRACTOR'S RESPONSIBILITY TO COORDINATE SUBCONTRACTORS AND THE ASSOCIATED CONTRACTS. WHEN DISCREPANCIES ARISE PERTAINING TO WHICH CONTRACTOR PROVIDES A PARTICULAR ITEM OF THE MECHANICAL CONTRACT OR WHICH CONTRACTOR PROVIDES FINAL CONNECTIONS FOR A PARTICULAR ITEM OF THE MECHANICAL CONTRACT, IT SHALL BE BROUGHT TO THE ATTENTION OF THE MECHANICAL CONTRACTOR, WHOSE DECISION SHALL BE FINAL.
- Y. THE LOCATIONS OF ALL ITEMS SHOWN ON THE DRAWINGS OR CALLED FOR IN THE SPECIFICATIONS THAT ARE NOT DEFINITELY FIXED BY DIMENSIONS ARE APPROXIMATE ONLY. THE EXACT LOCATIONS NECESSARY TO SECURE THE BEST CONDITIONS AND RESULTS MUST BE DETERMINED BY THE PROJECT SITE CONDITIONS AND SHALL HAVE THE APPROVAL OF THE ENGINEER BEFORE BEING INSTALLED. DO NOT SCALE DRAWINGS.
- Z. ALL MISCELLANEOUS STEEL REQUIRED TO ENSURE PROPER INSTALLATION AND AS SHOWN IN DETAILS FOR PIPING, DUCTWORK, AND EQUIPMENT (UNLESS OTHERWISE NOTED) SHALL BE FURNISHED AND INSTALLED BY THE MECHANICAL CONTRACTOR.
- AA. PROVIDE ACCESS PANELS FOR INSTALLATION IN WALLS AND CEILINGS, WHERE REQUIRED, TO SERVICE DAMPERS, VALVES, SMOKE DETECTORS, AND OTHER CONCEALED MECHANICAL EQUIPMENT. ACCESS PANELS SHALL BE TURNED OVER TO GENERAL CONTRACTOR FOR INSTALLATION.
- AB. ALL EQUIPMENT, PIPING, DUCTWORK, ETC., SHALL BE SUPPORTED AS DETAILED, SPECIFIED, AND REQUIRED TO PROVIDE A VIBRATION FREE INSTALLATION.
- AC. ALL DUCTWORK, PIPING AND EQUIPMENT SUPPORTED FROM STRUCTURAL STEEL SHALL BE COORDINATED WITH GENERAL CONTRACTOR. ALL ATTACHMENTS TO STEEL, BAR JOISTS, TRUSSES, OR JOIST GIRDERS SHALL BE AT PANEL POINTS. PROVIDE BEAM CLAMPS MEETING MSS STANDARDS.
- AD. WELDING TO STRUCTURAL MEMBERS SHALL NOT BE PERMITTED. THE USE OF C-CLAMPS SHALL NOT BE PERMITTED.
- AE. MECHANICAL EQUIPMENT, DUCTWORK, AND PIPING SHALL NOT BE SUPPORTED FROM METAL DECK.
- AF. ALL ROOF MOUNTED EQUIPMENT CURBS FOR EQUIPMENT PROVIDED BY THE MECHANICAL CONTRACTOR SHALL BE FURNISHED BY THE MECHANICAL CONTRACTOR AND INSTALLED BY THE GENERAL CONTRACTOR.
- AG. LOCATIONS AND SIZES OF ALL FLOOR, WALL, AND ROOF OPENINGS SHALL BE COORDINATED WITH ALL OTHER TRADES INVOLVED.
- AH. ALL OPENINGS IN FIRE WALLS DUE TO DUCTWORK, PIPING, CONDUIT, ETC., SHALL BE FIRE STOPPED WITH A PRODUCT SIMILAR TO 3M OR APPROVED EQUAL.
- AI. ALL AIR CONDITIONING CONDENSATE DRAIN LINES FROM EACH AIR HANDLING UNIT AND ROOFTOP UNIT SHALL BE PIPED FULL SIZE OF THE UNIT DRAIN OUTLET, WITH "P" TRAP AND PIPE TO NEAREST DRAIN, SEE DETAILS Y, SHOWN ON THE DRAWINGS OR THE CONTRACT SPECIFICATIONS FOR DEPTH OF AIR CONDITIONING CONDENSATE TRAP.
- AJ. REFER TO TYPICAL DETAILS FOR DUCTWORK, PIPING, AND EQUIPMENT INSTALLATION.

- A. IT IS THE INTENTION OF THE SPECIFICATIONS AND DRAWINGS TO CALL FOR COMPLETE, FINISHED WORK, TESTED AND READY FOR CONTINUOUS OPERATION. ANY APPARATUS, APPLIANCE, MATERIAL OR WORK NOT SHOWN ON THE DRAWINGS, BUT MENTIONED IN THE SPECIFICATIONS OR VICE VERSA, OR ANY INCIDENTAL ACCESSORIES NECESSARY TO MAKE THE WORK COMPLETE IN ALL RESPECTS AND READY FOR OPERATION, EVEN IF NOT PARTICULARLY SPECIFIED, SHALL BE PROVIDED BY THE CONTRACTOR OR HISHER SUB-SUBCONTRACTORS, WITHOUT ADDITIONAL EXPENSE TO THE OWNER.
- B. THE DRAWINGS ARE GENERALLY DIAGRAMMATIC. THE LOCATIONS OF ALL ITEMS THAT ARE NOT DEFINITELY FIXED BY DIMENSIONS ARE APPROXIMATE ONLY. THE EXACT LOCATIONS MUST BE DETERMINED AT THE SITE AND SHALL HAVE THE APPROVAL OF THE ARCHITECT BEFORE BEING INSTALLED. THE HVAC SUBCONTRACTOR SHALL FOLLOW DRAWINGS, INCLUDING SHOP DRAWINGS, IN LAYING OUT AND SHALL CHECK THE DRAWINGS OF OTHER TRADES TO VERIFY SPACES IN WHICH WORK WILL BE INSTALLED. MAINTAIN MAXIMUM HEADROOM AND SPACE CONDITIONS. WHERE SPACE CONDITIONS APPEAR INADEQUATE, NOTIFY THE ARCHITECT BEFORE PROCEEDING WITH THE INSTALLATION. THE HVAC SUBCONTRACTOR SHALL, WITHOUT EXTRA CHARGE, MAKE REASONABLE MODIFICATIONS IN THE LAYOUT AS NEEDED TO PREVENT CONFLICT WITH WORK OF OTHER TRADES OR FOR PROPER EXECUTION OF THE WORK.

DEMO NOTES

- A. EXISTING CONDITIONS SHOWN ARE BASED ON AND NON-DESTRUCTIVE FILED INVESTIGATION. FIELD VERIFY EXISTING CONDITIONS PRIOR TO COMMENCING WORK.
- B. PATCH PENETRATIONS THAT ARE NOT USED FOR NEW HVAC SYSTEM. COORDINATE WITH ARCHITECTURAL WORK.

- A. PROVIDE ALL MATERIALS AND EQUIPMENT AND PERFORM ALL LABOR REQUIRED TO INSTALL COMPLETE AND OPERABLE HVAC SYSTEMS AS INDICATED ON THE DRAWINGS, AS SPECIFIED AND AS REQUIRED BY CODE.
- B. CERTAIN ITEMS SUCH AS RISES AND DROPS IN DUCTWORK, ACCESS DOORS, VOLUME DAMPERS, ETC., ARE INDICATED ON THE CONTRACT DOCUMENT DRAWINGS FOR CLARITY FOR A SPECIFIC LOCATION REQUIREMENT AND SHALL NOT BE INTERPRETED AS THE EXTENT OF THE REQUIREMENTS FOR THESE ITEMS. CONTRACTOR IS REQUIRED TO INSTALL ACCESSORIES INCLUDED BUT NOT LIMITED TO ACCESS PANELS, DAMPERS INCLUDING FIRE, SMOKE AND COMBO), TEST PORTS AS REQUIRED BY CODE. FIRE AND SMOKE DAMPERS SHALL BE INSTALLED AT A MINIMUM OF ALL FIRE WALL PENETRATIONS UNLESS EXEMPT BY CODE. FIRE AND DUCT SMOKES SHALL BE INSTALLED WITH IN 5' OF THE DAMPER WHEN REQUIRED, UNLESS OTHERWISE REQUIRED.
- C. INSULATE THE FOLLOWING:
- a. ALL SUPPLY AIR, OUTDOOR AIR.
- b. EXHAUST AND RELIEF AIR BETWEEN THE MOTOR-OPERATED DAMPER AND PENETRATION OF THE BUILDING EXTERIOR.
- c. ALL DUCTWORK LOCATED IN UNCONDITIONED SPACES OR OUTSIDE BUILDING ENVELOPE.
- d. ALL DUCTWORK LOCATED IN ATTICS, WHETHER VENTILATED OR UNVENTILATED.
- e. ALL DUCTWORK BURIED EITHER OUTSIDE THE BUILDING OR BELOW FLOORS.
- f. ALL SURFACES SHOULD BE RESISTANT TO MOLD GROWTH AND RESIST EROSION, ACCORDING TO THE REQUIREMENTS OF ASHRAE STANDARD 62.1.
- D. IN CORRIDORS WHERE CEILING SPEAKERS AND AIR DIFFUSERS ARE INDICATED BETWEEN THE SAME LIGHT FIXTURES, INSTALL BOTH DEVICES AT THE QUARTER POINTS BETWEEN THE SAME FIXTURE.
- E. UNLESS OTHERWISE SHOWN, LOCATE ALL ROOM THERMOSTATS AND HUMIDISTATS 4'-0" (CENTERLINE) ABOVE FINISHED FLOOR. NOTIFY THE ENGINEER OF ANY ROOMS WHERE THE ABOVE LOCATION CANNOT BE MAINTAINED OR WHERE THERE IS A QUESTION ON LOCATION.
- F. ALL DUCTWORK SHALL BE CLEAR DOORS AND WINDOWS.
- G. ALL DUCTWORK DIMENSIONS, AS SHOWN ON THE DRAWINGS, ARE INTERNAL CLEAR DIMENSIONS AND DUCT SIZE SHALL BE INCREASED TO COMPENSATE FOR DUCT LINING THICKNESS.
- H. PROVIDE ALL 90 DEGREE SQUARE ELBOWS WITH DOUBLE RADIUS TURNING VANES UNLESS OTHERWISE INDICATED. ELBOWS IN DISHWASHER, KITCHEN, AND LAUNDRY EXHAUST SHALL BE UNVAINED SMOOTH RADIUS CONSTRUCTION WITH 11 RADIUS EQUAL TO 1 1/2 TIMES THE WIDTH OF THE DUCT. PROVIDE ACCESS DOORS UPSTREAM OF ALL TURNING VANES.
- I. COORDINATE DIFFUSER, REGISTER, AND GRILLE LOCATIONS WITH ARCHITECTURAL REFLECTED CEILING PLANS, LIGHTING, AND OTHER CEILING ITEMS AND MAKE MINOR DUCT MODIFICATIONS TO SUIT.
- J. FIELD ERECTED AND FACTORY ASSEMBLED AIR HANDLING UNIT COILS SHALL BE ARRANGED FOR REMOVAL FROM THE UPSTREAM SIDE WITHOUT DISMANTLING SUPPORTS. PROVIDE GALVANIZED STRUCTURAL STEEL SUPPORTS FOR ALL COILS (EXCEPT LOWEST COIL) IN BANKS OVER TWO COILS HIGH TO PERMIT INDEPENDENT REMOVAL OF ANY COIL.
- K. ALL AIR HANDLING UNITS SHALL OPERATE WITHOUT MOISTURE CARRYOVER.
- L. LOCATE ALL MECHANICAL EQUIPMENT (SINGLE DUCT, DUAL DUCT, VARIABLE VOLUME, CONSTANT VOLUME AND FAN POWERED BOXES, FAN COIL UNITS, CABINET HEATERS, UNIT HEATERS, UNIT VENTILATORS, COILS, STEAM HUMIDIFIERS, ETC.) FOR UNOBSTRUCTED ACCESS TO UNIT ACCESS PANELS, CONTROLS AND VALVING.
- M. FINNED TUBE RADIATION ENCLOSURES SHALL BE WALL TO WALL UNLESS OTHERWISE INDICATED. PROVIDE FLEXIBLE CONNECTIONS IN ALL DUCTWORK SYSTEMS (SUPPLY, RETURN, AND EXHAUST) CONNECTED TO AIR HANDLING UNITS, FANS, AND OTHER EQUIPMENT WHICH REQUIRE VIBRATION ISOLATION. FLEXIBLE CONNECTIONS SHALL BE PROVIDED AT THE POINT OF CONNECTION TO THE EQUIPMENT UNLESS OTHERWISE INDICATED.
- O. UNLESS OTHERWISE NOTED, ALL DUCTWORK IS OVERHEAD, TIGHT TO THE UNDERSIDE OF THE STRUCTURE, WITH SPACE FOR INSULATION IF REQUIRED.
- P. RUNS OF FLEXIBLE DUCT SHALL NOT EXCEED 5 FEET (EDIT MAXIMUM LENGTH OF FLEXIBLE DUCT TO SUIT PROJECT). 5 FEET MAXIMUM RECOMMENDED LENGTH OF FLEXIBLE DUCT.
- Q. ALL DUCTWORK SHALL BE COORDINATED WITH ALL TRADES INVOLVED. OFFSETS IN DUCTS, INCLUDING DIVIDED DUCTS AND TRANSITIONS AROUND OBSTRUCTIONS, SHALL BE PROVIDED AT NO ADDITIONAL COST TO THE OWNER.
- R. PROVIDE ACCESS DOORS IN DUCTWORK TO PROVIDE ACCESS FOR ALL SMOKE DETECTORS, FIRE DAMPERS, SMOKE DAMPERS, VOLUME DAMPERS, HUMIDIFIERS, COILS, AND OTHER ITEMS LOCATED IN THE DUCTWORK WHICH REQUIRE SERVICE AND/OR INSPECTION.
- S. PROVIDE ACCESS DOORS IN DUCTWORK FOR OPERATION, ADJUSTMENT, AND MAINTENANCE OF ALL FANS, VALVES, AND MECHANICAL EQUIPMENTS. ALL DUCTS SHALL BE GROUNDED ACROSS FLEXIBLE CONNECTIONS WITH FLEXIBLE COPPER GROUNDING STRAPS. GROUNDING STRAPS SHALL BE BOLTED OR SOLDERED TO BOTH THE EQUIPMENT AND THE DUCT.
- T. SMOKE DETECTORS SHALL BE FURNISHED AND WIRED BY THE ELECTRICAL CONTRACTOR. THE MECHANICAL CONTRACTOR SHALL BE RESPONSIBLE FOR MOUNTING THE SMOKE DETECTOR IN DUCTWORK AS SHOWN ON THE DRAWINGS AND IN ACCORDANCE WITH MANUFACTURER'S PRINTED INSTRUCTIONS.
- U. TERMINATE GAS VENTS FOR UNIT HEATERS, WATER HEATERS, HIGH PRESSURE PARTS WASHER, HIGH PRESSURE CLEANER, AND OTHER GAS APPLIANCES A MINIMUM OF 3'-0" ABOVE ROOF WITH RAIN CAP (EDIT APPLIANCES AND HEIGHT ABOVE ROOF TO MEET CODE AND TO SUIT PROJECT REQUIREMENTS). SEE SPECIFICATIONS FOR DUCTWORK GAUGES, BRACING, HANGERS, AND OTHER REQUIREMENTS.
- V. EXTERIOR LOUVERS ARE INDICATED FOR INFORMATION ONLY. DETAILED DESCRIPTIONS ARE PROVIDED IN THE ARCHITECTURAL SPECIFICATIONS.
- W. EXTERIOR LOUVERS ARE INDICATED FOR INFORMATION ONLY. LOUVER SIZES, LOCATIONS, AND DETAILS SHALL BE COORDINATED WITH GENERAL CONTRACTOR.
- X. EXTERIOR LOUVERS ARE INDICATED FOR INFORMATION ONLY. LOUVER SIZES, LOCATIONS, MOUNTING, AND DETAILS SHALL BE COORDINATED WITH OTHER TRADES INVOLVED.

- A. PROVIDE ALL MATERIALS AND EQUIPMENT AND PERFORM ALL LABOR REQUIRED TO INSTALL COMPLETE AND OPERABLE PIPING SYSTEMS AS INDICATED ON THE DRAWINGS, AS SPECIFIED AND AS REQUIRED BY CODE. ELEVATIONS AS SHOWN ON THE DRAWINGS ARE TO THE CENTERLINE OF ALL PRESSURE PIPING AND TO THE INVERT OF ALL GRAVITY PIPING.
- B. MAINTAIN A MINIMUM OF 3'-0" OF GROUND COVER OVER ALL UNDERGROUND HVAC PIPING BUT ENSURE FROST LINE IN CONSIDERED AND MET.
- C. UNLESS OTHERWISE NOTED, ALL CHILLED WATER AND HEATING WATER PIPING SHALL BE 3/4 INCH SIZE (EDIT SYSTEM TYPE OR PIPE SIZE TO SUIT PROJECT REQUIREMENTS).
- D. PROVIDE AN AIR VENT AT THE HIGH POINT OF EACH DROP ALL HYDRONIC PIPING SYSTEMS INCLUDING BUT NOT LIMITED TO IN THE HEATING WATER, CHILLED WATER, AND OTHER CLOSED WATER PIPING SYSTEMS (EDIT SYSTEM TYPES TO SUIT PROJECT REQUIREMENTS). ALL PIPING SHALL GRADE TO LOW POINTS. PROVIDE HOSE END DRAIN VALVES AT THE BOTTOM OF ALL RISERS AND LOW POINTS.
- F. UNLESS OTHERWISE NOTED, ALL PIPING IS OVERHEAD, TIGHT TO UNDERSIDE OF STRUCTURE OR SLAB, WITH SPACE FOR INSULATION IF REQUIRED.
- G. INSTALL PIPING SO THAT ALL VALVES, STRAINERS, UNIONS, TRAPS, FLANGES, AND OTHER APPURTENANCES REQUIRING ACCESS ARE ACCESSIBLE.
- H. ALL VALVES SHALL BE INSTALLED SO THAT VALVE REMAINS IN SERVICE WHEN EQUIPMENT OR PIPING ON EQUIPMENT SIDE OF VALVE IS REMOVED.
- I. ALL BALANCING VALVES AND BUTTERFLY VALVES SHALL BE PROVIDED WITH POSITION INDICATORS AND MAXIMUM ADJUSTABLE STOPS (MEMORY STOPS).
- J. PROVIDE CHAINWHEEL OPERATORS FOR ALL VALVES IN EQUIPMENT ROOMS MOUNTED GREATER THAN 7'-0" ABOVE FLOOR LEVEL. CHAIN SHALL EXTEND TO 7'-0" ABOVE FLOOR LEVEL.
- K. ALL VALVES (EXCEPT CONTROL VALVES) AND STRAINERS SHALL BE FULL SIZE OF PIPE BEFORE REDUCING SIZE TO MAKE CONNECTIONS TO EQUIPMENT AND CONTROLS.
- L. UNIONS AND/OR FLANGES SHALL BE INSTALLED AT EACH PIECE OF EQUIPMENT, IN BYPASSES, AND IN LONG PIPING RUNS (100 FEET OR MORE) TO PERMIT DISASSEMBLY FOR ALTERATION AND REPAIRS.
- M. PITCH STEAM RETURN LINES DOWNWARD IN THE DIRECTION OF STEAM FLOW (1 INCH IN 40 FEET) MINIMUM. PITCH STEAM RETURN LINES DOWNWARD IN THE DIRECTION OF CONDENSATE FLOW 1/2 INCH PER 10 FEET (1 INCH IN 20 FEET) MINIMUM. WHERE LENGTH OF BRANCH LINES ARE LESS THAN 8 FEET, PITCH BRANCH LINES TOWARD MAINS 1/2 INCH PER FOOT MINIMUM.
- N. PITCH UP ALL STEAM AND CONDENSATE RUNOUTS TO RISERS AND EQUIPMENT 1/2 INCH PER FOOT. WHERE THIS PITCH CANNOT BE OBTAINED, RUNOUTS OVER 8 FEET IN LENGTH SHALL BE ONE SIZE LARGER THAN NOTED.
- O. TAP ALL BRANCH LINES FROM TOP OF STEAM MAINS (45 DEGREES PREFERRED, 90 DEGREES ACCEPTABLE).
- P. PROVIDE AN END OF MAIN DRIP AT EACH RISE IN THE STEAM MAIN. PROVIDE CONDENSATE DRIPS AT THE BOTTOM OF ALL STEAM RISERS, DOWNFED RUNOUTS TO EQUIPMENT, RADIATORS, ETC., AT END OF MAINS AND LOW POINTS, AND AHEAD OF ALL PRESSURE REGULATORS, CONTROL VALVES, ISOLATION VALVES, AND EXPANSION JOINTS.
- Q. ON STRAIGHT STEAM PIPING RUNS WITH NO NATURAL DRAINAGE POINTS, INSTALL DRIP LEGS AT INTERVALS NOT EXCEEDING 200 FEET WHERE PIPE IS PITCHED DOWNWARD IN THE DIRECTION OF STEAM FLOW AND A MAXIMUM OF 100 FEET WHERE THE PIPE IS PITCHED UP SO THAT CONDENSATE FLOW IS OPPOSITE OF STEAM FLOW.
- R. STEAM TRAPS SHALL BE MINIMUM 3/4" SIZE.
- S. INSTALL ALL PIPING WITHOUT FORGING OR SPRINGING.
- T. ALL PIPING SHALL CLEAR DOORS AND WINDOWS.
- U. ALL VALVES SHALL BE ADJUSTED FOR SMOOTH AND EASY OPERATION.
- V. ALL PIPING WORK SHALL BE COORDINATED WITH ALL TRADES INVOLVED. OFFSETS IN PIPING AROUND OBSTRUCTIONS SHALL BE PROVIDED AT NO ADDITIONAL COST TO THE OWNER.
- W. PROVIDE FLEXIBLE CONNECTIONS IN ALL PIPING SYSTEMS CONNECTED TO PUMPS, CHILLERS, COOLING TOWERS, AND OTHER EQUIPMENT WHICH REQUIRE VIBRATION ISOLATION EXCEPT WATER COILS. FLEXIBLE CONNECTIONS SHALL BE PROVIDED AS CLOSE TO THE EQUIPMENT AS POSSIBLE OR AS INDICATED ON THE DRAWINGS.
- X. SLOPE REFRIGERANT PIPING ONE PERCENT IN THE DIRECTION OF OIL RETURN. LIQUID LINES MAY BE INSTALLED LEVEL.
- Y. INSTALL HORIZONTAL REFRIGERANT HOT GAS DISCHARGE PIPING WITH 1/2" PER 10 FEET DOWNWARD SLOPE AWAY FROM THE COMPRESSOR. Z. INSTALL HORIZONTAL REFRIGERANT SUCTION LINES WITH 1/2" PER 10 FEET DOWNWARD SLOPE TO THE COMPRESSOR, WITH NO LONG TRAPS OR DEAD ENDS WHICH MAY CAUSE OIL TO SEPARATE FROM THE SUCTION GAS AND RETURN TO THE COMPRESSOR IN DAMAGING SLUGS.
- Z. PROVIDE LINE SIZE LIQUID INDICATORS IN MAIN LIQUID LINE LEAVING CONDENSER OR RECEIVER. INSTALL MOISTURE-LIQUID INDICATORS IN LIQUID LINES BETWEEN FILTER DRYERS AND THERMOSTATIC EXPANSION VALVES AND IN LIQUID LINE TO RECEIVER.
- AA. PROVIDE LINE SIZE STRAINER UPSTREAM OF EACH AUTOMATIC VALVE. PROVIDE SHUTOFF VALVE ON EACH SIDE OF STRAINER.
- AB. PROVIDE PERMANENT FILTER DRYERS IN LOW TEMPERATURE SYSTEMS AND SYSTEMS USING HERMETIC COMPRESSORS.
- AC. PROVIDE REPLACEABLE CARTRIDGE FILTER DRYERS WITH THREE VALVE BYPASS ASSEMBLY FOR SOLENOID VALVES, ADJACENT TO RECEIVERS.
- AD. PROVIDE REFRIGERANT CHARGING VALVE CONNECTIONS IN LIQUID LINE BETWEEN RECEIVER SHUTOFF VALVE AND EXPANSION VALVE.

GENERAL SHEET NOTES

- A. PROVIDE ACCESS PANELS IN NON-ACCESSIBLE AREAS (RATED OR NON-RATED) ~~3/16~~ **3/8** INCH 12 COMBINATION FIRE SMOKE DAMPERS. INSTALL LARGER ACCESS PANELS FOR LARGER EQUIPMENT AS REQUIRED BY CODE. COORDINATE WITH ARCHITECT FOR APPROVAL OF FINAL LOCATIONS PRIOR TO INSTALLATION.
- B. PROVIDE FIRE STOPPING AT PASS THROUGH DUCT PENETRATIONS THROUGH RATED WALLS. DUCTWORK SHALL BE A MINIMUM 26 GA SHEET METAL. COORDINATE WITH OTHER TRADES THAT MAY HAVE PENETRANTS AROUND THE SAME AREA. REFER TO ARCHITECTURAL SHEETS FOR RATING ASSEMBLIES.
- C. INSULATION MATERIALS APPLIED TO DUCTWORK SHALL HAVE A FLAME SPREAD INDEX OF NOT MORE THAN 25 AND SMOKE DENSITY NOT EXCEEDING 50.
- D. REQUIRED OFFSETS, COMPONENTS, ACCESSORIES, AND FITTINGS MAY NOT BE SHOWN BUT SHALL BE PROVIDED AS REQUIRED TO AVOID INTERFERENCES WITH UNFORESSEEN COMPONENTS.
- E. PROVIDE DIELECTRIC UNIONS, GASKETS, AND FASTENERS AT DISSIMILAR METAL CONNECTIONS OF CONTACT POINTS.
- F. ROUTE CONDENSATE DRAIN PIPE TO FOLLOW EXISTING HVAC PIPING CHASES AND RISERS.
- G. MAINTAIN A 3'-0" DISTANCE FROM ENVIRONMENTAL EXHAUST OUTLETS (AS DEFINED IN RI SBC) TO BUILD OPENINGS AND 10'-0" DISTANCE TO MECHANICALLY FORCED AIR INLET.
- H. DUCT SIZE INDICATED ON PLANS ARE THE "FREE AREA" INSIDE DIMENSIONS OF THE DUCT. INCREASE THE SIZE OF THE DUCT TO ACCOMMODATE ACOUSTICAL SILENCERS AND/OR DUCT LINERS. FOR EXAMPLE, A DUCT SIZE SHOWN AS 12" X12" WITH 2" LINER SHALL BE SUPPLIED WITH A 16" X16" DUCT.
- I. ROOF SUPPORTS SHALL BE POSITIVELY ATTACHED TO THE ROOF STRUCTURE.
- J. INSTALL DUCT SYSTEMS IN THE FOLLOWING ORDER FROM LOWEST TO HIGHEST REFERENCED FROM THE FINISHED CEILING HEIGHT: - SUPPLY DUCT - RETURN/RELIEF DUCT - EXHAUST DUCT
- K. PROVIDE MANUAL SHEET METAL VOLUME DAMPER PRIOR TO EACH SUPPLY DIFFUSER/REGISTER AT THE BRANCH DUCT LOCATION. IF THE MAIN IS AN INACCESSIBLE LOCATION, CONTRACTOR TO PROVIDE CABLE OPERATED DAMPER (COD) FOR HIGH CEILINGS AND ALL DRYWALL CEILING LOCATIONS. DAMPERS SHALL BE INDICATED ON SHOP DRAWINGS FOR COORDINATION AND APPROVAL.
- L. ALL LOW VOLTAGE CONDUIT SHALL BE CONCEALED ABOVE CEILING AND WITHIN WALLS.

CONSULTANTS

MEP ENGINEER:
Andre Gill Engineering, LLC

40 Overlea Road
North Smithfield, RI 02896

T: 401.441.3414
E: andre.gill@engineering.com
W: www.andregillengineering.com

STAMP



(1)Owner acknowledges that such Documents are not intended or represented to be suitable for use on the Project unless completed by AGE, or for use or reuse by Owner or others on extensions of the Project, on any other project, or for any other use or purpose, without written verification or adaptation by AGE; (2)any such use or reuse, or any modification of the Documents, without written verification, completion, or adaptation by AGE, as appropriate for the specific purpose intended, will be at Owner's sole risk and without liability or legal exposure to AGE or to its officers, directors, members, partners, agents, employees, and Consultants (3)Owner shall indemnify and hold harmless AGE and its officers, directors, members, partners, agents, employees, and Consultants from all claims, damages, losses, and expenses, including attorneys' fees, arising out of or resulting from any use, reuse, or modification of the Documents without written verification, completion, or adaptation by AGE; and (4) such limited license to Owner shall not create any rights in third parties.



Project Title: HVAC AND ELECTRICAL UPGRADES		Project Number 2407
Location: FIELD STATION PHASE VI PRUDENCE ISLAND, RI		Drawing Scale 12" = 1'-0"
Drawing Title: MECHANICAL COVER SHEET		Drawing Number M0.0
Issue Date: 16SEP24	Approved By: AG	Drawn By: AGE
		Checked By: AG


A

B

C

D

3/6/2025 12:27:13 PM

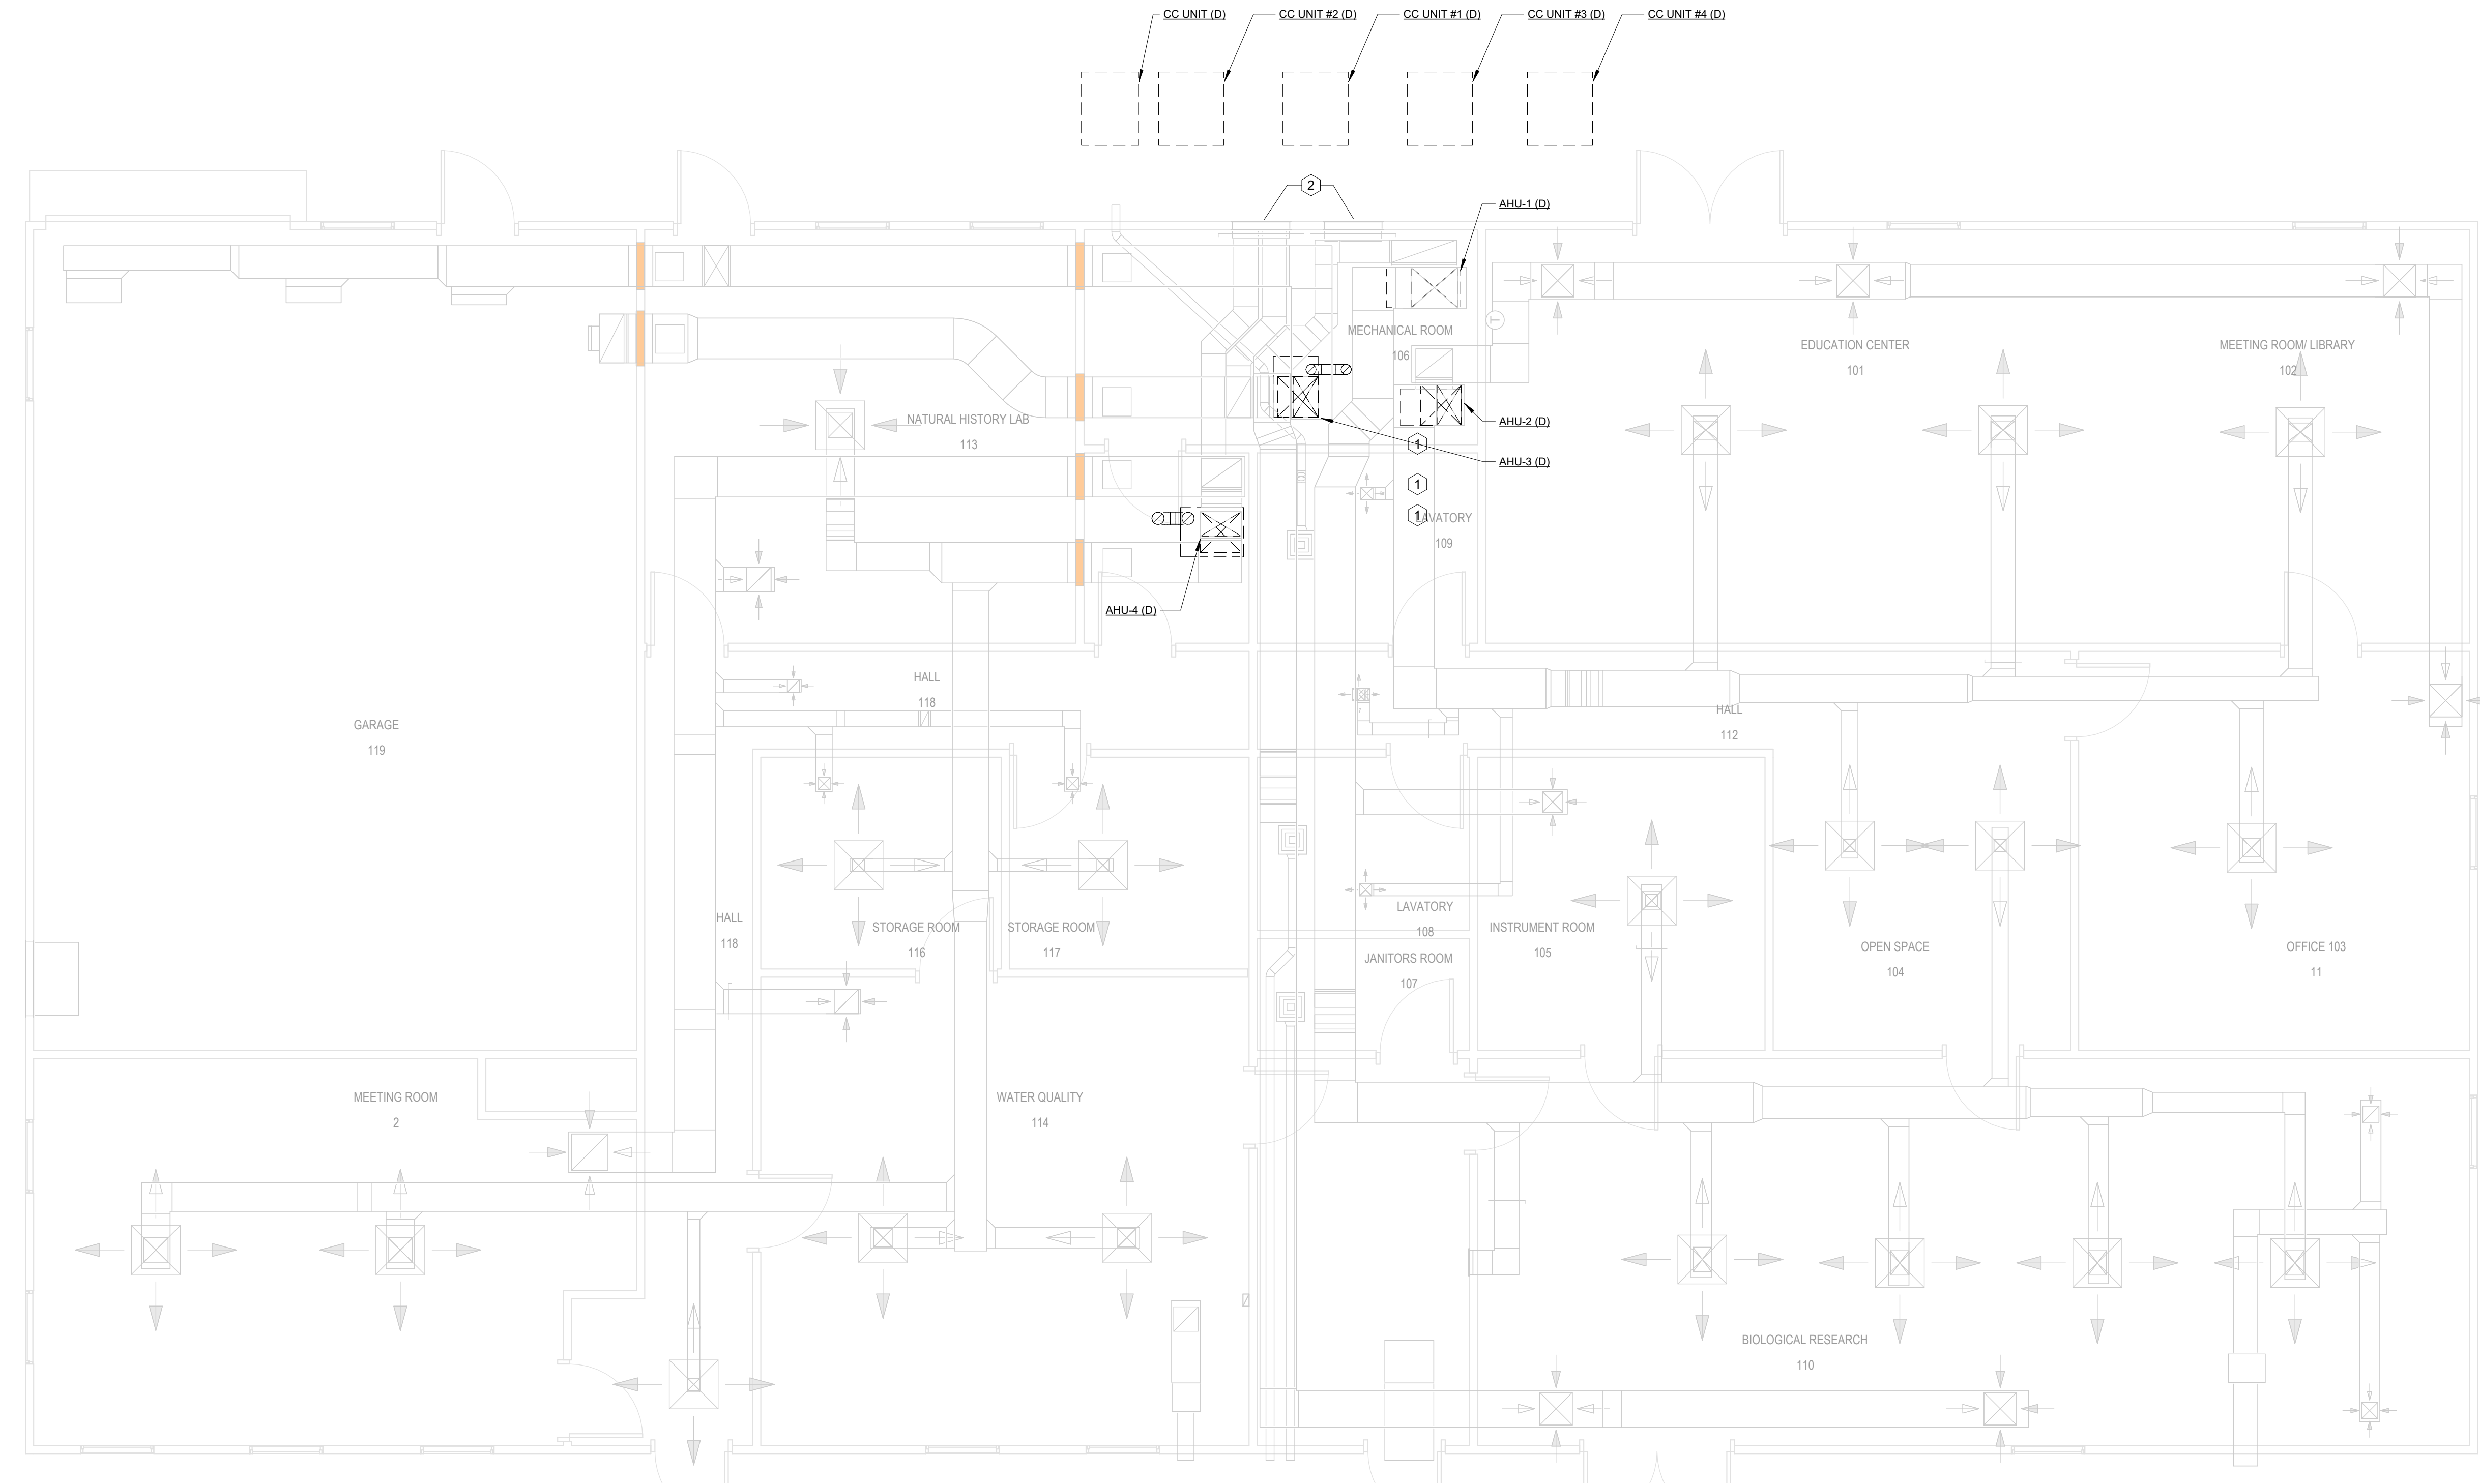


1 EXISTING MECHANICAL
1/4" = 1'-0"

(D) MECHANICAL CALLOUT NOTES	
#	NOTE
1	DEMO EXISTING FLUE DUCTWORK, CAP AND MAKE SAFE
2	EVALUATE LOUVERS FOR FIT FOR USE.

Revision 1	05MAR25
Revision:	Date:

CONSULTANTS	
MEP ENGINEER: Andre Gill Engineering, LLC	
40 Overlea Road North Smithfield, RI 02896	
T: 401.441.3414 E: andregillengineering.com W: www.andregillengineering.com	

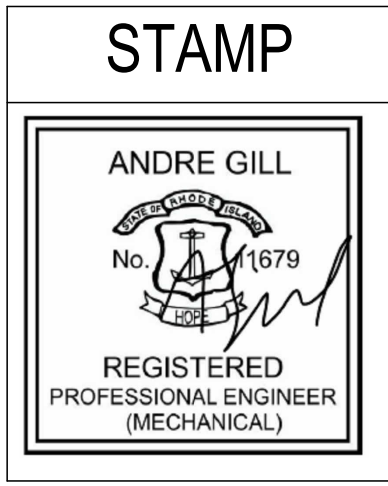

(1)Owner acknowledges that such Documents are not intended or represented to be suitable for use on the Project unless completed by AGE, or for use or reuse by Owner or others on extensions of the Project, on any other project, or for any other use or purpose, without written verification or adaptation by AGE; (2)any such use or reuse,or any modification of the Documents, without written verification, completion, or adaptation by AGE, as appropriate for the specific purpose intended, will be at Owner's sole risk and without liability or legal exposure to AGE or to its officers, directors, members, partners, agents, employees, and Consultants (3)Owner shall indemnify and hold harmless AGE and its officers, directors, members, partners, agents, employees, and Consultants from all claims, damages, losses, and expenses, including attorneys' fees, arising out of or resulting from any use, reuse, or modification of the Documents without written verification, completion, or adaptation by AGE; and (4) such limited license to Owner shall not create any rights in third parties.




Project Title: HVAC AND ELECTRICAL UPGRADES		Project Number 2407	
Location: FIELD STATION PHASE VI PRUDENCE ISLAND, RI		Drawing Scale As indicated	
Drawing Title: EXISTING MECHANICAL FLOOR PLAN - LEVEL 1		Drawing Number M1.1	
Issue Date: 16SEP24	Approved By: AG	Drawn By: AGE	Checked By: AG

DEMO NOTES

HVAC MECHANICAL DEMOLITION NOTES

- GENERAL NOTES:
 - COORDINATE ALL DEMOLITION WORK WITH THE OWNER'S REPRESENTATIVE AND OTHER TRADES PRIOR TO STARTING.
 - ALL WORK MUST COMPLY WITH APPLICABLE CODES, STANDARDS, AND PROJECT SPECIFICATIONS.
 - ENSURE ALL SYSTEMS, REFRIGERANT, OIL, AND ELECTRICAL, ARE MADE SAFE AND PROPERLY ISOLATED BEFORE COMMENCING ANY WORK.
 - PROTECT EXISTING SYSTEMS AND EQUIPMENT NOT SCHEDULED FOR DEMOLITION TO ENSURE THEY REMAIN OPERATIONAL.
 - NOT ALL PIPING AND EQUIPMENT ARE DEPICTED ON THE DRAWINGS, AS THEY WERE CREATED BASED ON MULTIPLE PROJECTS OVER THE YEARS AND NON-INVASIVE SITE WALKDOWNS. CONTRACTOR MUST THOROUGHLY REVIEW EXISTING SITE CONDITIONS AND BECOME INTIMATELY FAMILIAR WITH THE PROJECT SCOPE. ANY DISCREPANCIES OR QUESTIONS SHOULD BE REFERRED TO THE OWNER AND ENGINEER OF RECORD FOR CLARIFICATION.
- DEMOLITION PHASING:
 - THE EXISTING AIR HANDLING UNIT (AHU), SHALL BE REMOVED IN PHASES TO MINIMIZE DISRUPTION TO BUILDING OPERATIONS.
 - DISCONNECT AND REMOVE ELECTRICAL CONNECTIONS ASSOCIATED WITH THE AHU. VERIFY IF THE EXISTING ELECTRICAL COMPONENTS WILL BE REUSED OR REPLACED.
 - REMOVE THE AHU AND ASSOCIATED PIPING. PROTECT SURROUNDING AREAS, INCLUDING DUCTWORK AND LOUVERS, TO AVOID DAMAGE DURING DEMOLITION.
 - IN INSTANCES WHERE SYSTEMS SUCH AS OIL LINES OR BOILER BREECHING CANNOT BE FULLY SHUT DOWN DUE TO THEIR CONNECTION TO DOMESTIC HOT WATER SERVICE, THE PROJECT MAY REQUIRE ADDITIONAL PHASING TO MAINTAIN OPERATIONAL CONTINUITY.
- DUCTWORK AND LOUVERS:
 - EXISTING DUCTWORK AND LOUVERS WILL BE REUSED. PROTECT THESE COMPONENTS FROM DEBRIS AND DAMAGE DURING DEMOLITION.
 - CAP OPEN DUCT ENDS TEMPORARILY TO PREVENT CONTAMINATION.
- PIPING DEMOLITION:
 - RECOVER REFRIGERANT PER EPA GUIDELINES BEFORE DISCONNECTING REFRIGERANT LINES. PROVIDE DOCUMENTATION OF RECOVERY FOR THE PROJECT RECORD.
 - REMOVE ALL ABANDONED PIPING BACK TO ITS NEAREST ACTIVE CONNECTION OR TO A LOCATION DESIGNATED BY THE OWNER.
- ELECTRICAL DEMOLITION:
 - VERIFY WITH THE OWNER'S REPRESENTATIVE WHETHER THE EXISTING ELECTRICAL CONNECTIONS WILL BE REUSED OR REMOVED.
 - DISCONNECT POWER AND CONTROLS FROM THE AHU PER LOCAL ELECTRICAL CODES. LABEL AND IDENTIFY ALL WIRING FOR POTENTIAL REUSE.
- CLEAN-UP AND DISPOSAL:
 - REMOVE ALL DEMOLISHED MATERIALS FROM THE SITE AND DISPOSE OF THEM PER LOCAL REGULATIONS. CLEAN THE AREA THOROUGHLY AFTER DEMOLITION TO PREPARE FOR THE INSTALLATION OF NEW EQUIPMENT.
- DOCUMENTATION:
 - SUBMIT A DEMOLITION PLAN AND SCHEDULE TO THE OWNER'S REPRESENTATIVE FOR APPROVAL BEFORE STARTING WORK.
 - PROVIDE PHOTOGRAPHS AND WRITTEN DOCUMENTATION OF EXISTING CONDITIONS BEFORE AND AFTER DEMOLITION

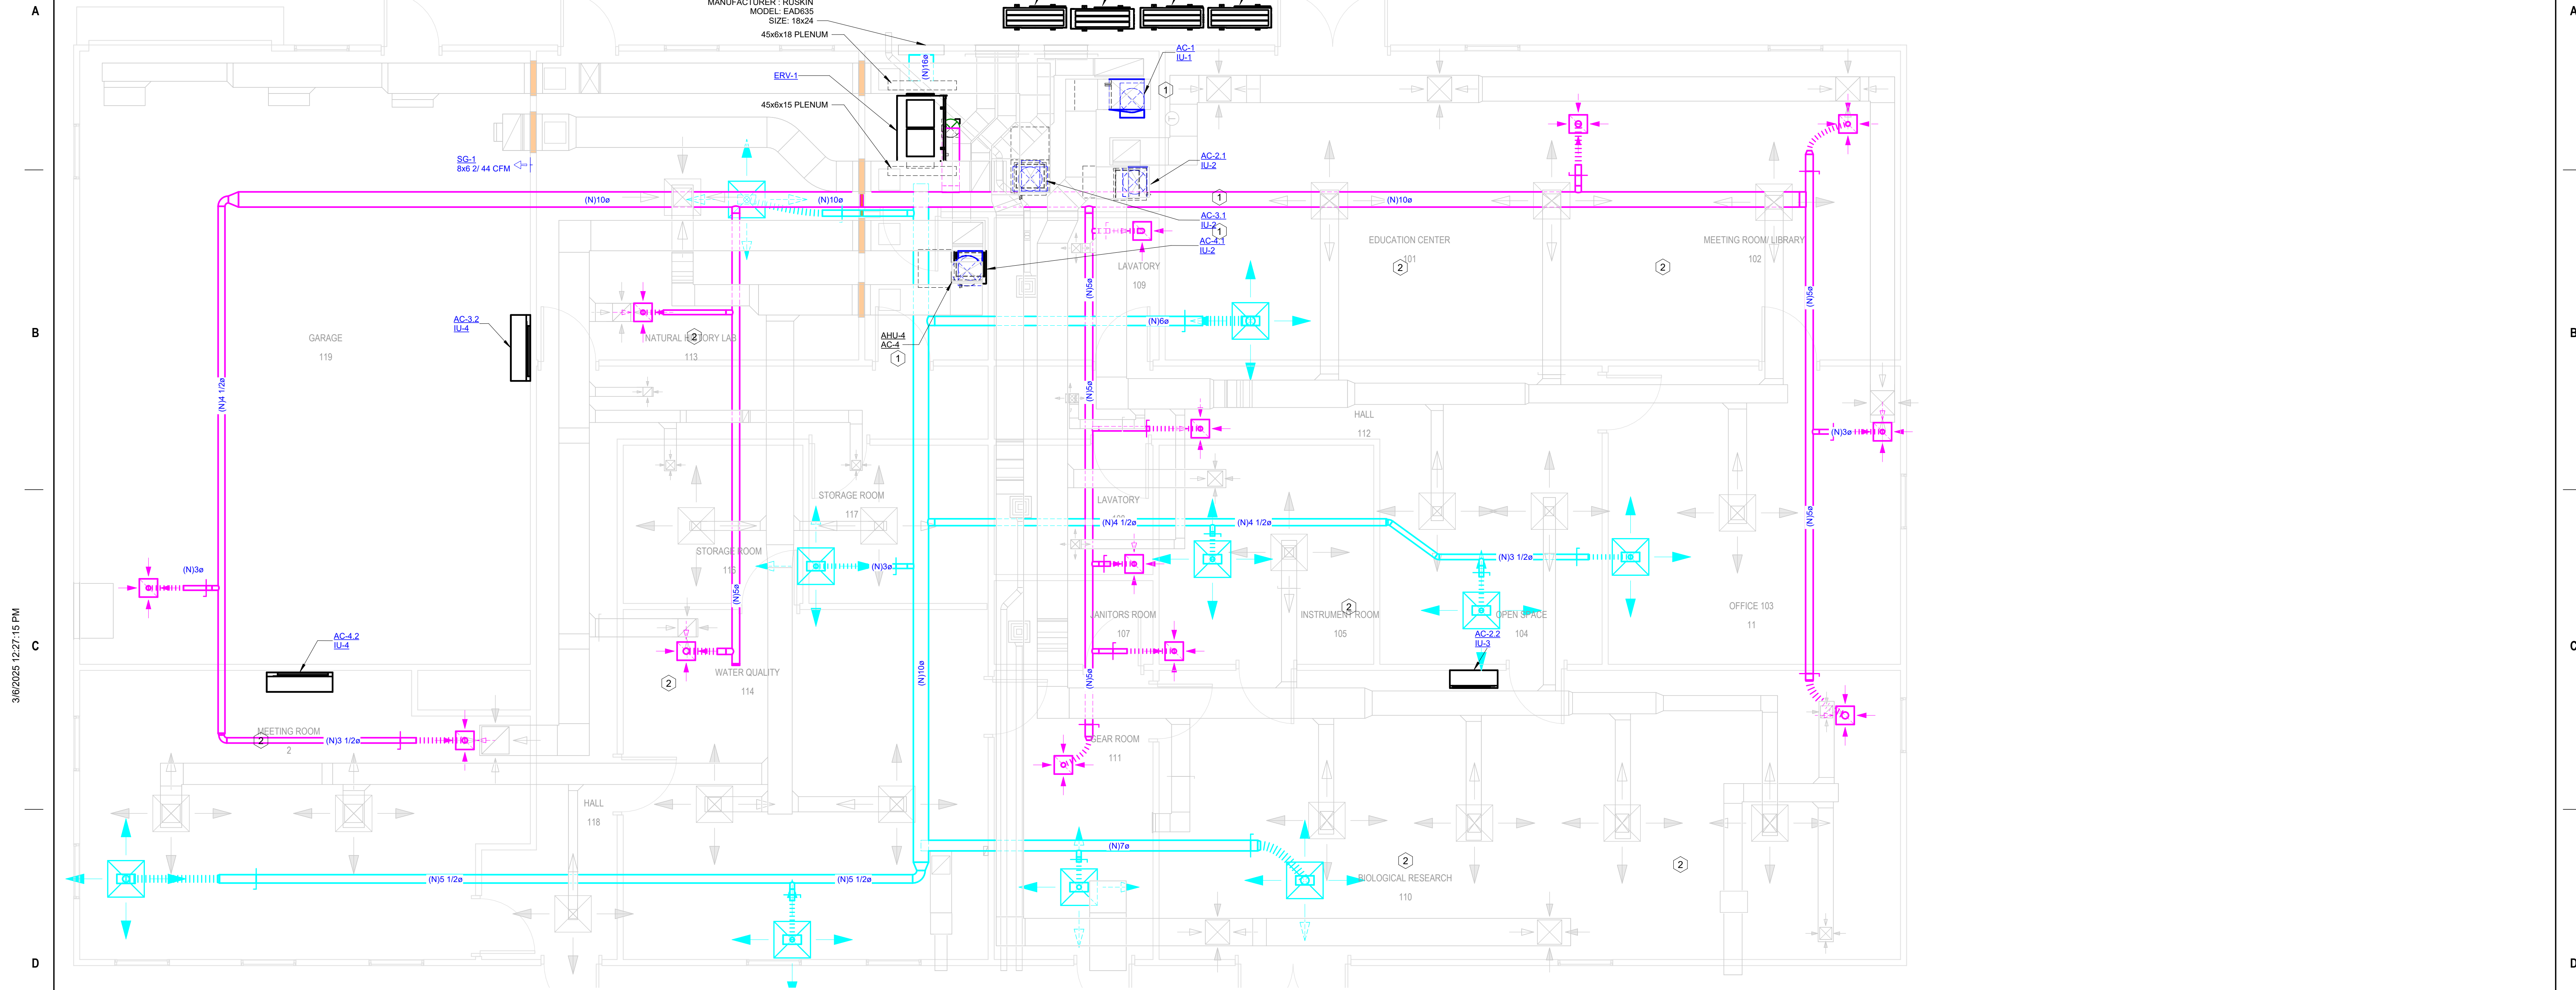

1 NEW CONSTRUCTION MECHANICAL
1/4" = 1'-0"

MECHANICAL CALLOUT NOTES	
#	NOTE
1	INSTALL AHU ON EQUIPMENT PAD
2	CONTRACTOR TO PROVIDE CURRENT AIR FLOW CONDITIONS AT EACH TERMINAL THROUGHOUT THE BUILDING AND PROVIDE FOR OF RECORD FOR CONFIRMATION OF AIRFLOW. UPON THE INSTALLATION OF NEW EQUIPMENT, THE AIRFLOW AT THE TERMINALS WILL BE RECONFIRMED AND BALANCED TO PROVIDE ADEQUATE AIRFLOW FOR HEATING AND COOLING.


SHEET NOTES

1. CONTRACTOR SHALL HAVE DISCRETION IN THE FINAL LAYOUT OF THE EQUIPMENT AS LONG AS IT MEETS THE INTENT OF THE PROJECT SCOPE.



Revision 1	05MAR25
Revision:	Date:

CONSULTANTS	
MEP ENGINEER:	
Andre Gill Engineering, LLC	
40 Overlea Road	
North Smithfield, RI 02896	
T: 401.441.3414	
E: andregillengineering.com	
W: www.andregillengineering.com	

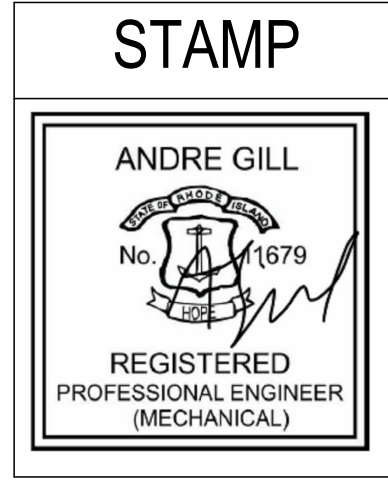

(1)Owner acknowledges that such Documents are not intended or represented to be suitable for use on the Project unless completed by AGE, or for use or reuse by Owner or others on extensions of the Project, on any other project, or for any other use or purpose, without written verification or adaptation by AGE; (2)any such use or reuse, or any modification of the Documents, without written verification, completion, or adaptation by AGE, as appropriate for the specific purpose intended, will be at Owner's sole risk and without liability or legal exposure to AGE or to its officers, directors, members, partners, agents, employees, and Consultants (3)Owner shall indemnify and hold harmless AGE and its officers, directors, members, partners, agents, employees, and Consultants from all claims, damages, losses, and expenses, including attorneys' fees, arising out of or resulting from any use, reuse, or modification of the Documents without written verification, completion, or adaptation by AGE; and (4) such limited license to Owner shall not create any rights in third parties.



Project Title: HVAC AND ELECTRICAL UPGRADES		Project Number 2407	
Location: FIELD STATION PHASE VI PRUDENCE ISLAND, RI		Drawing Scale 1/4" = 1'-0"	
Drawing Title: NEW CONSTRUCTION MECHANICAL FLOOR PLAN - LEVEL 1		Drawing Number M1.2	
Issue Date: 16SEP24	Approved By: AG	Drawn By: AGE	Checked By: AG

3/6/2025 12:27:15 PM

MITSUBISHI ELECTRIC TRANE HVAC US: CITY MULTI VRF INDOOR UNIT SCHEDULE																															
Outdoor Unit	Tag Reference	Type Mark	Model	Type	Nominal Cooling Capacity (BTU/h)	Nominal Heating Capacity (BTU/h)	Cooling Design Entering Temp DB/WB (°F)	Heating Design Entering Temp DB/WB (°F)	Corrected Capacity					Estimated Cooling Coil LAT (°F)	Estimated Heating Coil LAT (°F)	Refrig Pipe Dim Liquid/Suction (inch)	Fan Speed Setting	Peak Fan Airflow (cfm)	Max Fan ESP Setting 208V/230V (IN WG)	Sound Pressure Per Fan Speed 208V/230V (dBA)	Voltage / Phase	Electrical MCA/MPS	Condensate Removal Rate (gal/hr)	Notes / Options							
									Cooling Diversity Full/Partial (See Note 5, 6)	Cooling Total Capacity (BTU/h)	Cooling Sensible Capacity (BTU/h)	Heating Diversity Full/Partial (See Note 5, 6)	Heating Capacity (BTU/h)																		
CU-1	AC-1	IU-1	PVA-A36AA7	Multi Position	36,000	38,000	80.0/67.0	70	FULL DEMAND	38,404.8	28,741.3	FULL DEMAND	71,122.7	55.9	128.6	5/8 / 3/8	HIGH	1125		32 - 36 - 40	208/230V/1-phase	Powered by Outdoor	1.02	1, 2, 3, 4, 5							
CU-2	AC-2.1	IU-2	SVZ-KP36NA	Multi Position	33,400	33,500	80.0/67.0	70	FULL DEMAND	33,375.0	27,853.0	FULL DEMAND	67,538.6	51.1	138.8	3/8 / 5/8	HIGH	910	0.30/0.50/0.80	35-39-43	208/230V/1-phase	4.13/15	1.07	1, 2, 3, 4, 5							
CU-2	AC-2.2	IU-3	MSZ-GS12NA-UI	Wall -Mounted	12,000	14,400	80.0/67.0	70	FULL DEMAND	11,991.0	9,339.2	FULL DEMAND	14,364.4	57.4	104.1	1/4 / 3/8	HIGH	390		19-22-30-37-45/19-22-30-37-43	208/230V/1-phase	1/	0.34	1, 2, 3, 4, 5							
CU-3	AC-3.1	IU-2	SVZ-KP36NA	Multi Position	33,400	33,500	80.0/67.0	70	FULL DEMAND	33,376.3	27,853.4	FULL DEMAND	54,460.7	51.1	125.5	3/8 / 5/8	HIGH	910	0.30/0.50/0.80	35-39-43	208/230V/1-phase	4.13/15	1.07	1, 2, 3, 4, 5							
CU-3	AC-3.2	IU-4	MSZ-GS24NA-UI	Wall -Mounted	22,400	27,600	80.0/67.0	70	FULL DEMAND	22,384.1	16,789.8	FULL DEMAND	16,757.2	57.4	92.2	1/4 / 5/8	HIGH	701		34-41-47-53/32-41-47-52	208/230V/1-phase	1/	0.69	1, 2, 3, 4, 5							
CU-4	AC-4.1	IU-2	SVZ-KP36NA	Multi Position	33,400	33,500	80.0/67.0	70	FULL DEMAND	33,376.3	27,853.4	FULL DEMAND	54,460.7	51.1	125.5	3/8 / 5/8	HIGH	910	0.30/0.50/0.80	35-39-43	208/230V/1-phase	4.13/15	1.07	1, 2, 3, 4, 5							
CU-4	AC-4.2	IU-4	MSZ-GS24NA-UI	Wall -Mounted	22,400	27,600	80.0/67.0	70	FULL DEMAND	22,384.1	16,789.8	FULL DEMAND	16,757.2	57.4	92.2	1/4 / 5/8	HIGH	701		34-41-47-53/32-41-47-52	208/230V/1-phase	1/	0.69	1, 2, 3, 4, 5							
NOTES & OPTIONS: 1. NOMINAL COOLING CAPACITIES ARE BASED ON INDOOR COIL EAT OF 80/67°F (DB/WB), OUTDOOR OF 95°F (DB) 2. NOMINAL HEATING CAPACITIES ARE BASED ON INDOOR COIL EAT OF 70°F (DB), OUTDOOR OF 43°F (WB) 3. SEE SCHEMATIC PIPING/CONTROL DIAGRAM FOR INDICATION OF REQUIRED INDOOR UNIT REMOTE CONTROLLERS, SYSTEM CONTROLLERS, AND INTEGRATION DEVICES. 4. SEE OUTDOOR UNIT SCHEDULE FOR OUTDOOR AMBIENT CONDITIONS, CONNECTED CAPACITY, AND OTHER FACTORS ASSOCIATED WITH CORRECTED CAPACITIES 5. FULL DEMAND CORRECTED CAPACITY INCLUDES DE-RATE ASSOCIATED WITH INDOOR VS. OUTDOOR CONNECTED CAPACITY INDICATED ON OUTDOOR UNIT SCHEDULE FOR ASSOCIATED SYSTEM. PARTIAL CORRECTED CAPACITY ASSUMES SUFFICIENT DIVERSITY EXISTS SUCH THAT THE CONNECTED CAPACITY DE-RATE DOES NOT APPLY. IT IS THE DESIGNER'S RESPONSIBILITY TO ENSURE "DIAMOND SYSTEM BUILDER" IS SET IN THE APPROPRIATE OUTPUT CAPACITY SETTING (FULL DEMAND/PARTIAL DEMAND) PRIOR TO GENERATING THIS SCHEDULE. 6. IT IS RECOMMENDED TO ALWAYS BASE HEATING CORRECTED CAPACITY ON FULL DEMAND. 7. PROVIDE 10KW ELECTRIC HEAT KIT PROVIDE 10KW ELECTRIC HEAT KIT																															
MITSUBISHI ELECTRIC TRANE HVAC US: CITY MULTI VRF OUTDOOR UNIT SCHEDULE																															
System Tag	Type Mark	Model Number	Modules	Nominal Cooling Capacity (BTU/h)	Nominal Heating Capacity (BTU/h)	Cooling Efficiency (I)EER [SEER]	EER2 [SEER2]	Heating COP @ 47°F [HSFP]	Nom System Connected Capacity (% of NOM)	Design Cooling Outdoor Temp DB (°F)	Design Heating Outdoor Temp WB (°F)	Refrig Pipe Dim High/Low Pressure (inch) (See Note 4)	Corrected Cooling Total Capacity (BTU/h)	Corrected Heating Capacity (BTU/h)	Sound Pressure (dBA)	Inverter Driven Compressor Type / Quantity	Preliminary Added Field Charge (See Note 5)	Electrical-Per Module				Notes / Options									
																		208/230													
																		Voltage / Phase	MCA 208/230	RFS	MOCP										
CU-1	OU-1	PUZ-HA36NKA		36,000	38,000	0 [18.20]	0 []	0 [11.20]	100.0 %	89.0	4.3	3/8 / 5/8	38,404.8	37,001.3	52/53	SCROLL/1	0.0	208/230V / 1-phase	26	35	42	1, 2, 3, 4, 5, 6, 7, 8, 9									
CU-2	OU-2	MXZ-SM48NAMHZ2-UI	P48	48,000	54,000	0	19.5	3.600	100.0 %	89.0	4.3	3/8 / 5/8	47,624.8	50,355.8	51/54	SCROLL/1	6.9	208/230V / 1-phase	51	45	86	1, 2, 3, 4, 5, 6, 7, 8, 9									
CU-3	OU-3	MXZ-SM60NAM2-UI	P60	60,000	66,000	0	11.9	3.740	100.0 %	89.0	4.3	3/8 / 3/4	59,768.8	37,096.5	58/59	SCROLL/1	8.5	208/230V / 1-phase	55	50	90	1, 2, 3, 4, 5, 6, 7, 8, 9									
CU-4	OU-3	MXZ-SM60NAM2-UI	P60	60,000	66,000	0	11.9	3.740	100.0 %	89.0	4.3	3/8 / 3/4	59,768.8	37,096.5	58/59	SCROLL/1	8.5	208/230V / 1-phase	55	50	90	1, 2, 3, 4, 5, 6, 7, 8, 9									
NOTES & OPTIONS: 1. NOMINAL COOLING CAPACITIES ARE BASED ON INDOOR COIL EAT OF 80/67°F (DB/WB), OUTDOOR OF 95°F (DB) 2. NOMINAL HEATING CAPACITIES ARE BASED ON INDOOR COIL EAT OF 70°F (DB), OUTDOOR OF 43°F (WB). 3. EFFICIENCY VALUES FOR EER, IEER, COP ARE BASED ON AHRI 1230 TEST METHOD FOR MIXTURE OF DUCTED & NON-DUCTED INDOOR UNITS. 4. FOR SYSTEMS WITH MULTIPLE MODULES, REFRIGERANT PIPE DIMENSIONS INDICATE TOTAL SYSTEM COMBINED PIPING DOWNSTREAM OF MODULE TWINNING. 5. ADDED FIELD CHARGE LISTED IS IN ADDITION TO FACTORY CHARGE, THIS MUST BE UPDATED BASED UPON FINAL AS-BUILT PIPING LAYOUT. 6. FACTORY REPRESENTATIVES SHALL REVIEW THE PROJECT PRIOR TO AND THROUGHOUT THE INSTALLATION OF CITY MULTI EQUIPMENT 7. FACTORY REPRESENTATIVES SHALL STARTUP AND COMMISSION CITY MULTI EQUIPMENT UPON COMPLETION OF EQUIPMENT INSTALLATIONS 8. FACTORY REPRESENTATIVES SHALL PROVIDE ON-SITE ASSISTANCE FOR THE BMS INTEGRATION OF THE CITY MULTI EQUIPMENT 9. FACTORY REPRESENTATIVES SHALL PROVIDE END-USER TRAINING ON THE CITY MULTI EQUIPMENT UPON COMPLETION OF THE INSTALLATION OF EQUIPMENT																															
				CONSULTANTS										STAMP		(1)Owner acknowledges that such Documents are not intended or represented to be suitable for use on the Project unless completed by AGE, or for use or reuse by Owner or others on extensions of the Project, on any other project, or for any other use or purpose, without written verification or adaptation by AGE; (2)any such use or reuse,or any modification of the Documents, without written verification, completion, or adaptation by AGE, as appropriate for the specific purpose intended, will be at Owner's sole risk and without liability or legal exposure to AGE or to its officers, directors, members, partners, agents, employees, and Consultants (3)Owner shall indemnify and hold harmless AGE and its officers, directors, members, partners, agents, employees, and Consultants from all claims, damages, losses, and expenses, including attorneys' fees, arising out of or resulting from any use, reuse, or modification of the Documents without written verification, completion, or adaptation by AGE; and (4) such limited license to Owner shall not create any rights in third parties. 															
				MEP ENGINEER:																											
				Andre Gill Engineering, LLC																											
				40 Overlea Road North Smithfield, RI 02896																											
				T: 401.441.3414 E: andregillengineering.com W: www.andregillengineering.com																											
Revision 1 Revision:				05MAR25 Date:												Project Title: HVAC AND ELECTRICAL UPGRADES						Project Number 2407									
																Location: FIELD STATION PHASE VI PRUDENCE ISLAND, RI						Drawing Scale 1" = 80'-0"									
																Drawing Title: SCHEDULES						Drawing Number M5.1									
																Issue Date: 16SEP24		Approved By: AG		Drawn By: AGE		Checked By: AG									
1				2				3				4				5				6				7				8			

Quick Results

Connection Summary

Indoor Units: 1 / 1 to 1

Capacity: 36 / 18 to 36 (100.0%)

* Connectable capacity is not actual capacity.

Total Pipe Length: 0.0 / 245.0 feet

Refrigerant

System Refrigerant: R410A

Additional Field-Charge: 0.00 lb

Total System Charge: 11.46 lb

Correction Factors

Cooling Heating

Outdoor Temperature: 1.07 0.98

Piping Length: 1.00 1.00

Defrosting: - 1.00

User Derate: 1.00 1.00

Outdoor Altitude: 1.00 1.00

1.07 0.97

Conditions

Cooling Heating

Indoor Dry Bulb 80.0 °F Indoor Dry Bulb 70.0 °F

Indoor Wet Bulb 67.0 °F

Indoor Humidity 51.8 % Outdoor Dry Bulb 5.0 °F

Outdoor Wet Bulb 4.3 °F

Outdoor Dry Bulb 89.0 °F Outdoor Humidity 77.5 %

Quick Results

Connection Summary

Indoor Units: 2 / 2 to 8

Capacity: 48 / 24 to 62 (100.0%)

* Connectable capacity is not actual capacity.

Total Pipe Length: 40.0 / 492.0 feet

Furthest Actual: 40.0 / 262.0 feet

Furthest Equiv.: 43.9 / 262.0 feet

Refrigerant

System Refrigerant: R410A

Additional Field-Charge: 6.88 lb

Total System Charge: 17.46 lb

Correction Factors

Cooling Heating

Outdoor Unit Capacity: 1.00 1.00

Outdoor Temperature: 1.01 0.99

Piping Length: 0.98 0.99

Defrosting: - 0.95

User Derate: 1.00 1.00

Outdoor Altitude: 1.00 1.00

0.99 0.93

Conditions

Cooling Heating

Indoor Dry Bulb 80.0 °F Indoor Dry Bulb 70.0 °F

Indoor Wet Bulb 67.0 °F

Indoor Humidity 51.8 % Outdoor Dry Bulb 5.0 °F

Outdoor Wet Bulb 4.3 °F

Outdoor Dry Bulb 89.0 °F Outdoor Humidity 77.5 %

PUZ-HA36NKA

CU-1

3/8 / 5/8

0.0ft (0)

PVA-A36AA7

1 / 1 / BIO RESEARCH LAB 110, GEAR ROOM 111, OPEN SPACE 104, INSTRUMENT 105 / AC-1

38.405 BTU/h (28,741 BTU/h)

71.123 BTU/h

Est. Cooling Discharge Air Temp: 55.9

Est. Heating Discharge Air Temp: 128.6

MXZ-SM48NAMHZ2-U1 2.0 ft

47,625 BTU/h

50,356 BTU/h

CU-2

3/8 / 5/8

40.0ft (4)

PAC-MKA32BC 0.0 ft

45,366 BTU/h (37,192 BTU/h)

81,903 BTU/h

SVZ-KP36NA

3/8 / 5/8

0.0ft (0)

2 / 2 / MEETING ROOM/ LIBRARY 102, EDUCATION 101, OPEN SPACE 104, WOMEN RR 108, HALL 112, MENS RR 109 / AC-2.1

2.0 ft

33,375 BTU/h (27,853 BTU/h)

67,539 BTU/h

Est. Cooling Discharge Air Temp: 51.1

Est. Heating Discharge Air Temp: 138.8

MSZ-GS12NA-U1

1/4 / 3/8

0.0ft (0)

3 / 3 / BIO RESEARCH LAB 110 / AC-2.2

8.0 ft

11,991 BTU/h (9,339 BTU/h)

14,364 BTU/h

Est. Cooling Discharge Air Temp: 57.4

Est. Heating Discharge Air Temp: 104.1

3/6/2025 12:27:16 PM

C

CONSULTANTS

MEP ENGINEER:

Andre Gill Engineering, LLC

40 Overlea Road

North Smithfield, RI 02896

T: 401.441.3414

E: andregillengineering.com

W: www.andregillengineering.com

STAMP

ANDRE GILL

No. 1679

REGISTERED PROFESSIONAL ENGINEER (MECHANICAL)

(1)Owner acknowledges that such Documents are not intended or represented to be suitable for use on the Project unless completed by AGE, or for use or reuse by Owner or others on extensions of the Project, on any other project, or for any other use or purpose, without written verification or adaptation by AGE; (2)any such use or reuse, or any modification of the Documents, without written verification, completion, or adaptation by AGE, as appropriate for the specific purpose intended, will be at Owner's sole risk and without liability or legal exposure to AGE or to its officers, directors, members, partners, agents, employees, and Consultants (3)Owner shall indemnify and hold harmless AGE and its officers, directors, members, partners, agents, employees, and Consultants from all claims, damages, losses, and expenses, including attorneys' fees, arising out of or resulting from any use, reuse, or modification of the Documents without written verification, completion, or adaptation by AGE; and (4) such limited license to Owner shall not create any rights in third parties.

AGE

Project Title: HVAC AND ELECTRICAL UPGRADES

Location: FIELD STATION PHASE VI PRUDENCE ISLAND, RI

Drawing Title: VRF UNITS 1 AND 2

Issue Date: 16SEP24

Approved By: AG

Drawn By: AGE

Project Number 2407

Drawing Scale

Drawing Number M7.1A


Checked By: AG

Narragansett Bay Research Reserve

3/6/2025 12:27:16 PM

3/6/2025 12:27:16 PM


Flow Diagram: VRF INDOOR UNIT CD

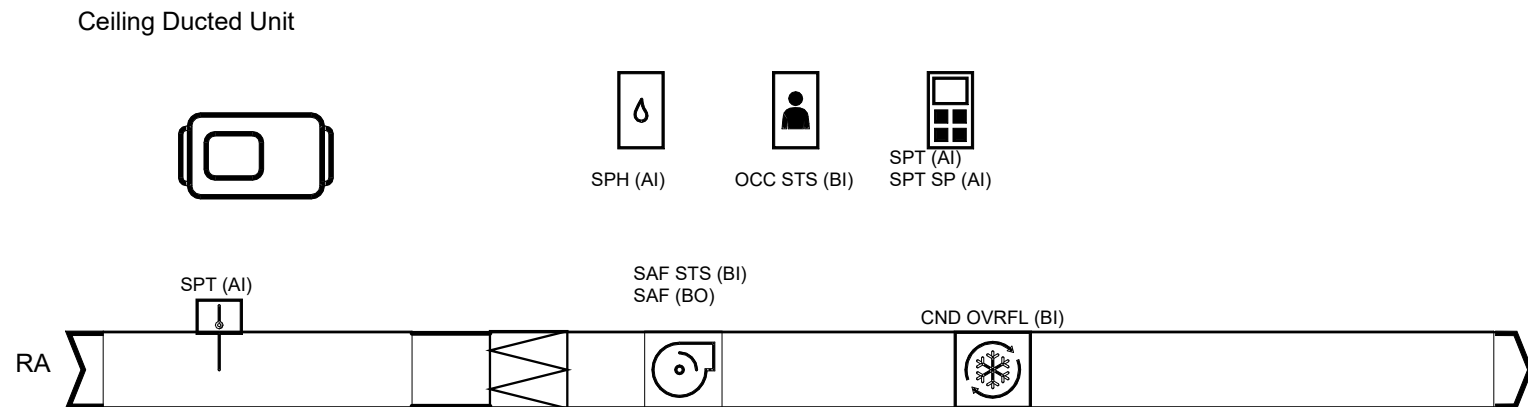

Points List: VRF INDOOR UNIT CD [QTY: 3]

System Point Description	POINTS					ALARMS				
	GRAPHIC	ANALOG HARDWARE INPUT (AI)	BINARY HARDWARE INPUT (BI)	ANALOG HARDWARE OUTPUT (AO)	BINARY HARDWARE OUTPUT (BO)	SOFTWARE POINT (SFT)	HARDWARE INTERLOCK (HDW)	WIRELESS (WLS)	NETWORK (NET)	LOW ANALOG LIMIT
										BINARY
										LATCH DIAGNOSTIC
										SENSOR FAIL
										COMMUNICATION FAIL
CONDENSATE OVERFLOW DETECTION LOCAL CND OVRFL			X							X
FAN SPEED STATUS SAF STS		X								
SPACE HUMIDITY SENSOR LOCAL SPH	X	X								
SPACE OCCUPANCY STATUS OCC STS		X								
SPACE TEMPERATURE LOCAL SPT	X	X								
SPACE TEMPERATURE SETPOINT LOCAL SPT SP	X	X								
SPACE TEMPERATURE (TH1) SPT	X									
SUPPLY FAN SPEED SAF				X						
ALARM CODE ALM				X						
ALARM MESSAGE ALM MSG				X						
BAS COMMUNICATION STATE BAS COM				X						X
EXPANSION VALVE STATE XV RATE				X						
FILTER TIMER HOURS FIL HRS				X						
GAS PIPE TEMPERATURE (TH3) VAPT				X						
GAS PIPE TEMPERATURE (TH4) VAPT				X						
INDOOR LEV RATE LEV RATE				X						
LIQUID PIPE TEMPERATURE (TH2) LIQT				X						
OCCUPIED COOLING SETPOINT OCC CLG SP				X						
OCCUPIED HEATING SETPOINT OCC HTG SP				X						
SUBCOOL (SC) SC				X						
SUPERHEAT (SH) SH				X						
UNOCCUPIED COOLING SETPOINT UNOCC CLG SP				X						
UNOCCUPIED HEATING SETPOINT UNOCC HTG SP				X						

Flow Diagram: VRF INDOOR UNIT WA

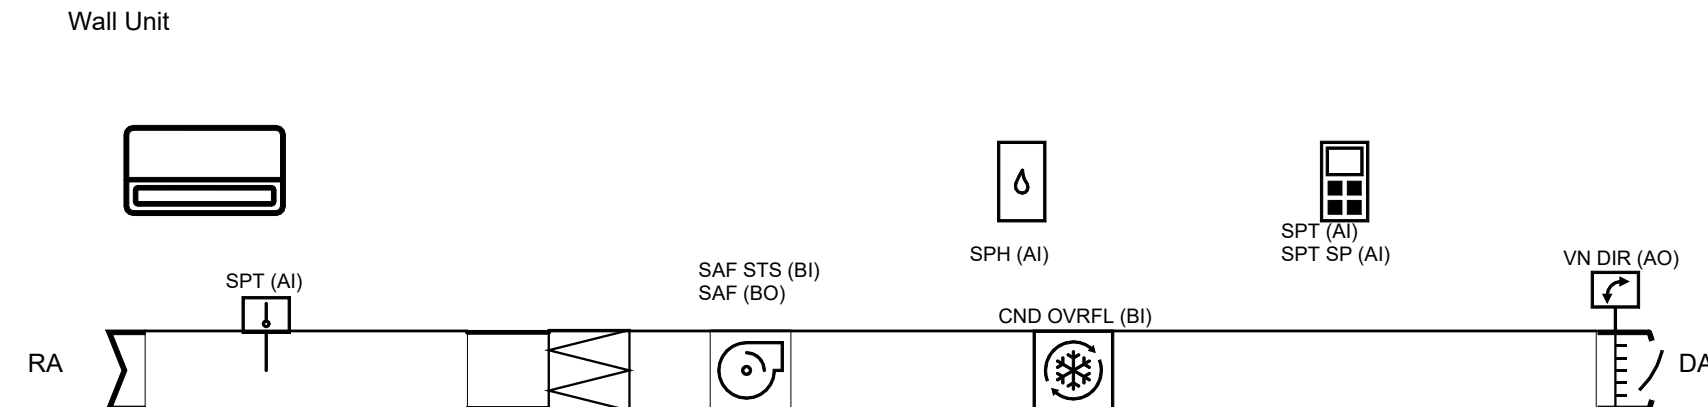

Points List: VRF INDOOR UNIT

System Point Description	POINTS					ALARMS				
	GRAPHIC	ANALOG HARDWARE INPUT (AI)	BINARY HARDWARE INPUT (BI)	ANALOG HARDWARE OUTPUT (AO)	BINARY HARDWARE OUTPUT (BO)	SOFTWARE POINT (SFT)	HARDWARE INTERLOCK (HDW)	WIRELESS (WLS)	NETWORK (NET)	LOW ANALOG LIMIT
										BINARY
										LATCH DIAGNOSTIC
										SENSOR FAIL
										COMMUNICATION FAIL
CONDENSATE OVERFLOW DETECTION LOCAL CND OVRFL			X							X
FAN SPEED STATUS SAF STS		X								
SPACE HUMIDITY SENSOR LOCAL SPH	X	X								
SPACE TEMPERATURE LOCAL SPT	X	X								
SPACE TEMPERATURE SETPOINT LOCAL SPT SP	X	X								
SPACE TEMPERATURE (TH1) SPT	X									
SUPPLY FAN SPEED SAF				X						
VANE DIRECTION VN DIR	X		X							
ALARM CODE ALM				X						
ALARM MESSAGE ALM MSG				X						
BAS COMMUNICATION STATE BAS COM				X						X
EXPANSION VALVE STATE XV RATE				X						
FILTER TIMER HOURS FIL HRS				X						
GAS PIPE TEMPERATURE (TH3) VAPT				X						
GAS PIPE TEMPERATURE (TH4) VAPT				X						
INDOOR LEV RATE LEV RATE				X						
LIQUID PIPE TEMPERATURE (TH2) LIQT				X						
OCCUPIED COOLING SETPOINT OCC CLG SP				X						
OCCUPIED HEATING SETPOINT OCC HTG SP				X						
SUBCOOL (SC) SC				X						
SUPERHEAT (SH) SH				X						
UNOCCUPIED COOLING SETPOINT UNOCC CLG SP				X						
UNOCCUPIED HEATING SETPOINT UNOCC HTG SP				X						


Points List: VRF OUTDOOR UNIT

System Point Description	POINTS					ALARMS				
	GRAPHIC	ANALOG HARDWARE INPUT (AI)	BINARY HARDWARE INPUT (BI)	ANALOG HARDWARE OUTPUT (AO)	BINARY HARDWARE OUTPUT (BO)	SOFTWARE POINT (SFT)	HARDWARE INTERLOCK (HDW)	WIRELESS (WLS)	NETWORK (NET)	LOW ANALOG LIMIT
										BINARY
										LATCH DIAGNOSTIC
										SENSOR FAIL
										COMMUNICATION FAIL
COMPRESSOR DISCHARGE TEMPERATURE CMP DT										
COMPRESSOR OUTPUT(S) CMP OUT				X						
DEMAND (EMERGENCY) STOP CMP ES			X							
HIGH SIDE SATURATION TEMPERATURE OAT HSAT TEMP		X								
INVERTER HEAT SINK TEMPERATURE IVR TEMP		X								
LOW SIDE SATURATION TEMPERATURE LSAT TEMP		X								
OUTDOOR AIR TEMPERATURE OUTDOOR UNIT FAN OUTPUT(S) OFN SPD		X		X						
POWER 3PH BUT ONLY MEASURING ONE LEG CURRENT (PH-A) CMP PHA		X								
POWER 3PH BUT ONLY MEASURING ONE LEG CURRENT (PH-C) CMP PHC		X								
REFRIGERANT HIGH SIDE PRESSURE HPRESS		X								
REFRIGERANT LOW SIDE PRESSURE LPRESS		X								
SUCTION LINE TEMPERATURE SUC TEMP		X								
ALARM CODE ALM				X						
ALARM MESSAGE ALM MSG				X						
COMPRESSOR OPERATION STATUS CMP STS				X						
LOW AMBIENT CAPACITY CONTROL LAMB CAP				X						
OPERATING SPEED OF THE MAIN ODU CMP FQ				X						
OPERATIONAL MODE STATUS MOD STS				X						
OUTDOOR UNIT FAN STATE OFN STS				X						
POWER LINE FREQUENCY PWR FQ				X						
REVERSING VALVE POSITION REV VLV POS				X						



Revision 1	05MAR25
Revision:	Date:

CONSULTANTS	
MEP ENGINEER: Andre Gill Engineering, LLC	
40 Overlea Road North Smithfield, RI 02896	
T: 401.441.3414 E: andregillengineering.com W: www.andregillengineering.com	

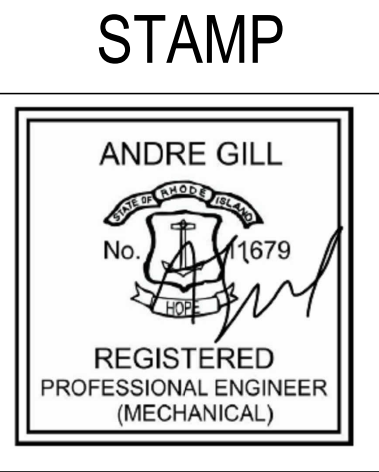

(1)Owner acknowledges that such Documents are not intended or represented to be suitable for use on the Project unless completed by AGE, or for use or reuse by Owner or others on extensions of the Project, on any other project, or for any other use or purpose, without written verification or adaptation by AGE; (2)any such use or reuse, or any modification of the Documents, without written verification, completion, or adaptation by AGE, as appropriate for the specific purpose intended, will be at Owner's sole risk and without liability or legal exposure to AGE or to its officers, directors, members, partners, agents, employees, and Consultants (3)Owner shall indemnify and hold harmless AGE and its officers, directors, members, partners, agents, employees, and Consultants from all claims, damages, losses, and expenses, including attorneys' fees, arising out of or resulting from any use, reuse, or modification of the Documents without written verification, completion, or adaptation by AGE; and (4) such limited license to Owner shall not create any rights in third parties.



Project Title: HVAC AND ELECTRICAL UPGRADES		Project Number 2407	
Location: FIELD STATION PHASE VI PRUDENCE ISLAND, RI		Drawing Scale	
Drawing Title: VRF CONTROLS POINTS		Drawing Number M7.3	
Issue Date: 16SEP24	Approved By: AG	Drawn By: AGE	Checked By: AG

ERV CONTROL SEQUENCE


1. GENERAL OVERVIEW
- A. THE ERV UNIT PROVIDES MECHANICAL VENTILATION WITH ENERGY RECOVERY FROM EXHAUST AIR. THE SYSTEM OPERATES IN RESPONSE TO OCCUPANCY AND ENVIRONMENTAL CONDITIONS TO OPTIMIZE ENERGY EFFICIENCY AND INDOOR AIR QUALITY (IAQ). THE ERV CONTROL SEQUENCE INTEGRATES WITH THE BUILDING AUTOMATION SYSTEM (BAS) FOR MONITORING AND ALARMS.
2. OPERATING MODES
- A. NORMAL VENTILATION MODE (OCCUPIED)
- a. THE ERV OPERATES CONTINUOUSLY WHEN THE SPACE IS OCCUPIED.
- B. OUTDOOR AIR (OA) AND EXHAUST AIR (EA) DAMPERS MODULATE TO MAINTAIN THE DESIGNED VENTILATION RATE.
- C. SUPPLY FAN (SF) AND EXHAUST FAN (EF) OPERATE AT THE MINIMUM REQUIRED AIRFLOW.
- D. ENERGY RECOVERY WHEEL (OR CORE) TRANSFERS HEAT AND MOISTURE BETWEEN EXHAUST AND SUPPLY AIR STREAMS.
- B. DEMAND-CONTROLLED VENTILATION (DCV) (OPTIONAL - IF CO₂ SENSORS INSTALLED)
- A. IF CO₂ CONCENTRATION EXCEEDS THE SETPOINT (E.G., 800 PPM), THE ERV INCREASES OUTDOOR AIRFLOW UP TO THE MAXIMUM LIMIT.
- B. WHEN CO₂ LEVELS DROP BELOW 750 PPM, AIRFLOW REVERTS TO THE MINIMUM VENTILATION RATE.
- C. ECONOMIZER MODE (IF OUTDOOR CONDITIONS ALLOW FREE COOLING)
- A. IF OUTDOOR TEMPERATURE AND HUMIDITY CONDITIONS MEET ECONOMIZER CRITERIA (E.G., OA TEMPERATURE < 55°F AND RH < 60%), THE ENERGY RECOVERY DEVICE IS BYPASSED, AND OA DAMPERS MODULATE TO MAXIMIZE FREE COOLING.
- D. DEFROST MODE (FOR FROST PROTECTION IN COLD CLIMATES)
- A. IF THE OUTDOOR AIR TEMPERATURE DROPS BELOW A THRESHOLD (E.G., 32°F), THE ERV ACTIVATES FROST PROTECTION:
- B. THE ENERGY RECOVERY WHEEL SPEED MODULATES (IF APPLICABLE) OR STOPS TO PREVENT FROST BUILDUP.
- C. THE UNIT MAY CYCLE TO A RECIRCULATION MODE OR PREHEAT COIL (IF INSTALLED) TO PREVENT FROST FORMATION.
- D. ALARMS ARE TRIGGERED IF FROST CONDITIONS PERSIST.
- E. UNOCCUPIED MODE
- A. THE ERV REMAINS OFF UNLESS OVERRIDDEN BY A BAS SCHEDULE OR IAQ DEMAND SIGNAL.
- B. THE SYSTEM CAN CYCLE PERIODICALLY (E.G., 15-MINUTE PURGE EVERY 4 HOURS) TO PREVENT AIR STAGNATION.
3. SYSTEM COMPONENTS AND CONTROL LOGIC
- A. FANS
- A. SUPPLY AND EXHAUST FANS (SF & EF): OPERATE IN UNISON TO MAINTAIN PROPER BUILDING PRESSURIZATION.
- B. VARIABLE SPEED CONTROL (IF APPLICABLE): FANS MODULATE BASED ON AIRFLOW SENSORS OR STATIC PRESSURE SETPOINTS.
- B. ENERGY RECOVERY WHEEL OR CORE
- A. THE WHEEL (IF ROTARY) RUNS AT FULL SPEED DURING NORMAL OPERATION AND MODULATES OR SHUTS DOWN IN ECONOMIZER OR DEFROST MODE.
- B. A BYPASS DAMPER (IF PRESENT) OPENS DURING ECONOMIZER MODE.
- C. DAMPERS
- A. OUTDOOR AIR (OA) AND EXHAUST AIR (EA) DAMPERS: MODULATE BASED ON AIRFLOW REQUIREMENTS.
- B. BYPASS DAMPER (IF APPLICABLE): OPENS DURING ECONOMIZER MODE AND DEFROST MODE.
- D. SENSORS
- A. TEMPERATURE SENSORS: OA, RETURN AIR (RA), SUPPLY AIR (SA), AND EXHAUST AIR (EA).
- B. HUMIDITY SENSORS: OA AND RA TO OPTIMIZE ENTHALPY RECOVERY.
- C. CO₂ SENSORS (IF DEMAND CONTROL IS IMPLEMENTED).
- E. ALARMS & FAULTS
- A. HIGH CO₂ LEVELS (> 1,000 PPM).
- B. SUPPLY OR EXHAUST FAN FAILURE.
- C. FROST PROTECTION ALARM.
- D. HIGH OR LOW TEMPERATURE LIMITS EXCEEDED.
- F. INTEGRATION WITH BUILDING AUTOMATION SYSTEM (BAS)
- A. ERV OPERATION IS MONITORED VIA BACNET OR MODBUS PROTOCOL.
- B. BAS CAN OVERRIDE SCHEDULES OR ADJUST SETPOINTS REMOTELY.
- C. DATA LOGGING FOR TEMPERATURE, HUMIDITY, CO₂, AND FAN SPEEDS

3/6/2025 12:27:17 PM



Revision 1	05MAR25
Revision:	Date:

CONSULTANTS
MEP ENGINEER: Andre Gill Engineering, LLC 40 Overlea Road North Smithfield, RI 02896 T: 401.441.3414 E: andregillengineering.com W: www.andregillengineering.com

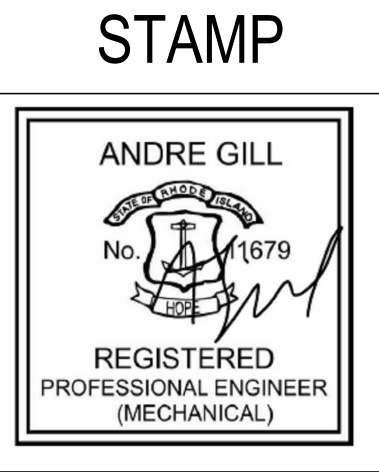

(1)Owner acknowledges that such Documents are not intended or represented to be suitable for use on the Project unless completed by AGE, or for use or reuse by Owner or others on extensions of the Project, on any other project, or for any other use or purpose, without written verification or adaptation by AGE; (2)any such use or reuse,or any modification of the Documents, without written verification, completion, or adaptation by AGE, as appropriate for the specific purpose intended, will be at Owner's sole risk and without liability or legal exposure to AGE or to its officers, directors, members, partners, agents, employees, and Consultants (3)Owner shall indemnify and hold harmless AGE and its officers, directors, members, partners, agents, employees, and Consultants from all claims, damages, losses, and expenses, including attorneys' fees, arising out of or resulting from any use, reuse, or modification of the Documents without written verification, completion, or adaptation by AGE; and (4) such limited license to Owner shall not create any rights in third parties.



Project Title: HVAC AND ELECTRICAL UPGRADES		Project Number 2407	
Location: FIELD STATION PHASE VI PRUDENCE ISLAND, RI		Drawing Scale 12" = 1'-0"	
Drawing Title: SEQUENCE OF OPERATIONS		Drawing Number M7.5	
Issue Date: 16SEP24	Approved By: AG	Drawn By: AGE	Checked By: AG

A

B

C

D

E

9/25/2024 5:27:28 PM

A

B

C

D

E

GENERAL SHEET NOTES

1.

CONFIRM EXISTING CIRCUITING AS SHOWN PRIOR TO START OF WORK. NOTIFY ENGINEER IF FIELD CONDITIONS DIFFER.
2.

DEMOLISH FEEDERS TO MECHANICAL EQUIPMENT AS SHOWN. CONFIRM CIRCUIT SUPPLIES EQUIPMENT SHOWN ON MECHANICAL DRAWINGS TO BE DEMOLISHED.

KEYNOTES


- 1

AFTER NEW WORK SHOWN ON E0.3 FOR NEW SERVICE AND PANEL SP IS COMPLETED, REMOVE CONNECTION BETWEEN GROUNDED CONDUCTOR (NEUTRAL) AND EQUIPMENT GROUND. THIS BOND MAY ONLY TAKE PLACE IN ONE LOCATION WHICH IS THE NEW PANEL SP.
- 2

AFTER NEW WORK SHOWN ON E0.3 FOR NEW SERVICE AND PANEL SP IS COMPLETED, REMOVE CONNECTION TO GROUNDING ELECTRODES. MAINTAIN GROUNDING ELECTRODES TO CONNECT TO NEW PANEL SP. REFER TO E0.3 FOR NEW WORK.
- 3

AFTER NEW WORK SHOWN ON E0.3 FOR NEW SERVICE AND PANEL SP IS COMPLETED, COORDINATE REMOVAL/RELOCATION OF METER WITH RHODE ISLAND ENERGY. AFTER METER IS REMOVED FROM METER ENCLOSURE, DEMOLISH METER ENCLOSURE.
- 4

DEMOLISH RISER, CONDUIT, AND CIRCUIT WIRING AFTER WORK IN KEYNOTE 3 ON THIS SHEET IS COMPLETED.

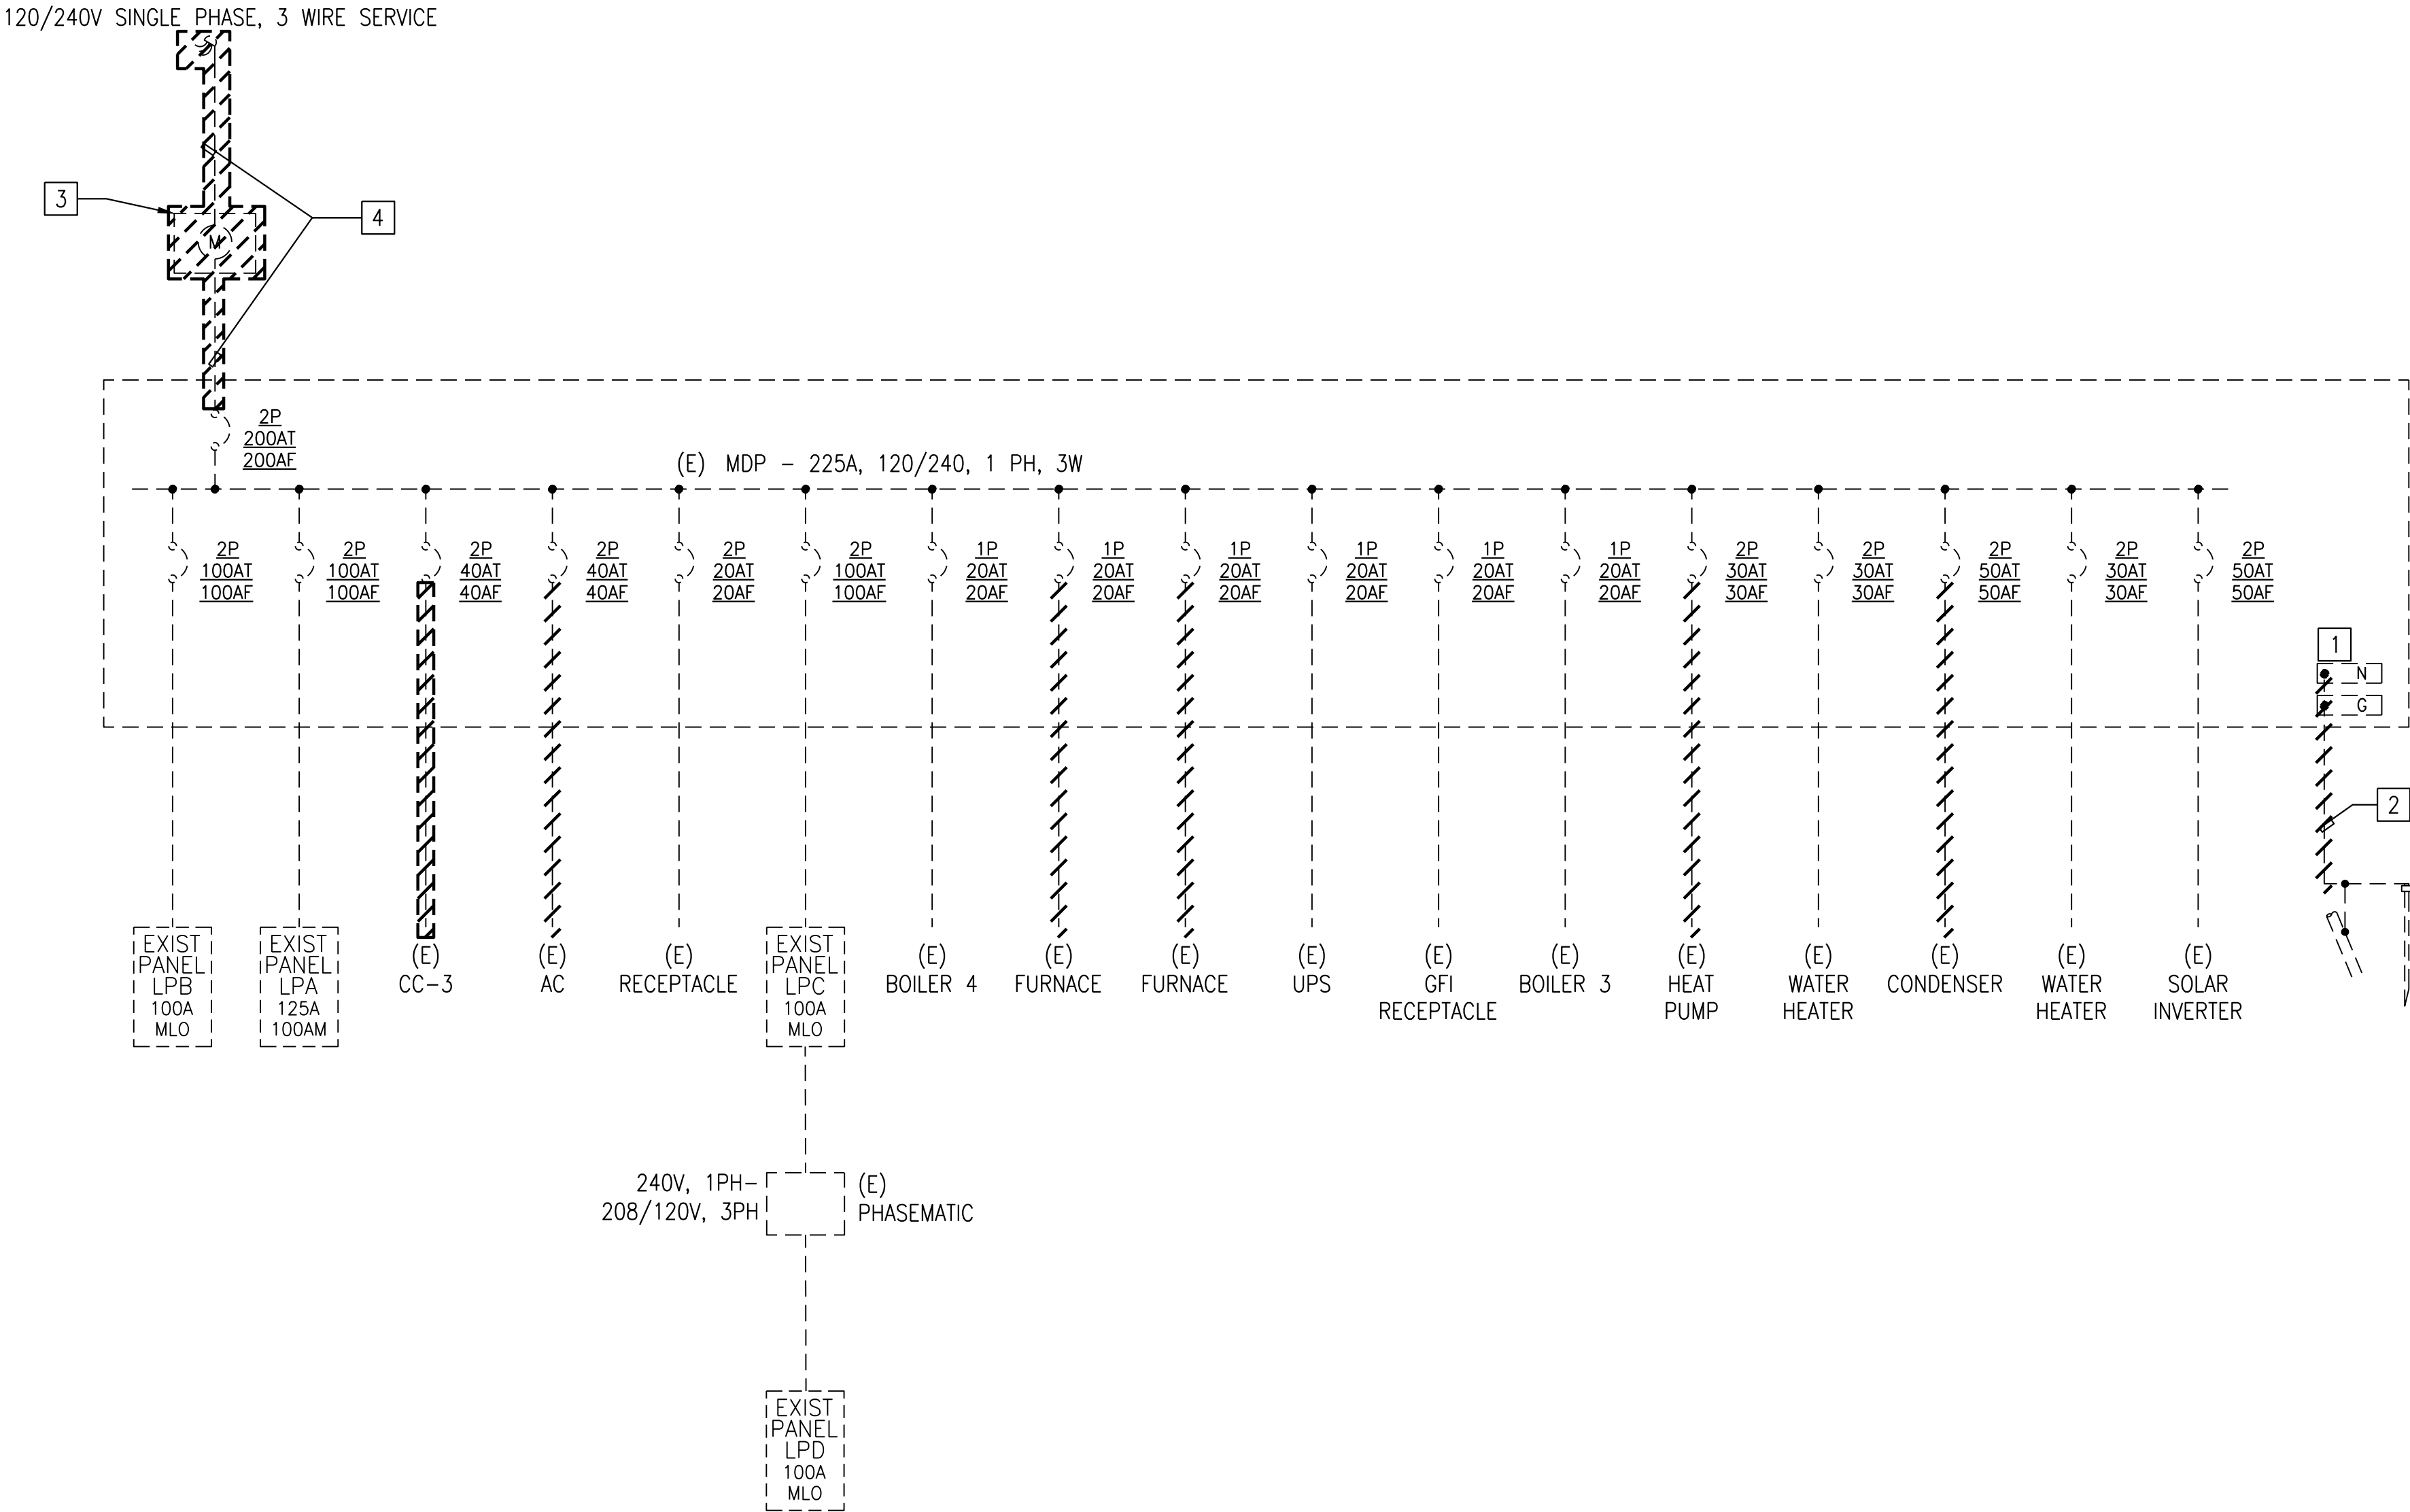

ELECTRICAL SINGLE-LINE DIAGRAM (DEMOLITION)

SCALE: NTS

PLAN NORTH



REV 1 - MECHANICAL EQUIPMENT	05MAR25
Revision:	Date:

CONSULTANTS
MEP ENGINEER: Andre Gill Engineering, LLC 40 Overlea Road North Smithfield, RI 02896 T: 401.441.3414 E: andregillengineering.com W: www.andregillengineering.com

STAMP
12511 REGISTERED PROFESSIONAL ENGINEER (ELECTRICAL) Michael O'Brien

(1)Owner acknowledges that such Documents are not intended or represented to be suitable for use on the Project unless completed by AGE, or for use or reuse by Owner or others on extensions of the Project, on any other project, or for any other use or purpose, without written verification or adaptation by AGE; (2)any such use or reuse, or any modification of the Documents, without written verification, completion, or adaptation by AGE, as appropriate for the specific purpose intended, will be at Owner's sole risk and without liability or legal exposure to AGE or to its officers, directors, members, partners, agents, employees, and Consultants (3)Owner shall indemnify and hold harmless AGE and its officers, directors, members, partners, agents, employees, and Consultants from all claims, damages, losses, and expenses, including attorneys' fees, arising out of or resulting from any use, reuse, or modification of the Documents without written verification, completion, or adaptation by AGE; and (4) such limited license to Owner shall not create any rights in third parties.



Project Title: THE NARRAGANSETT BAY NATIONAL ESTUARINE RESEARCH RESERVE		Project Number 2407	
Location: FIELD STATION PHASE VI PRUDENCE ISLAND		Drawing Scale	
Drawing Title: ELECTRICAL SINGLE-LINE DIAGRAM (DEMOLITION)		Drawing Number E0.2	
Issue Date: 09/16/24	Approved By: AGE	Drawn By: AGE	Checked By: MTO

A


B

C

D

E

9/25/2024 5:27:28 PM

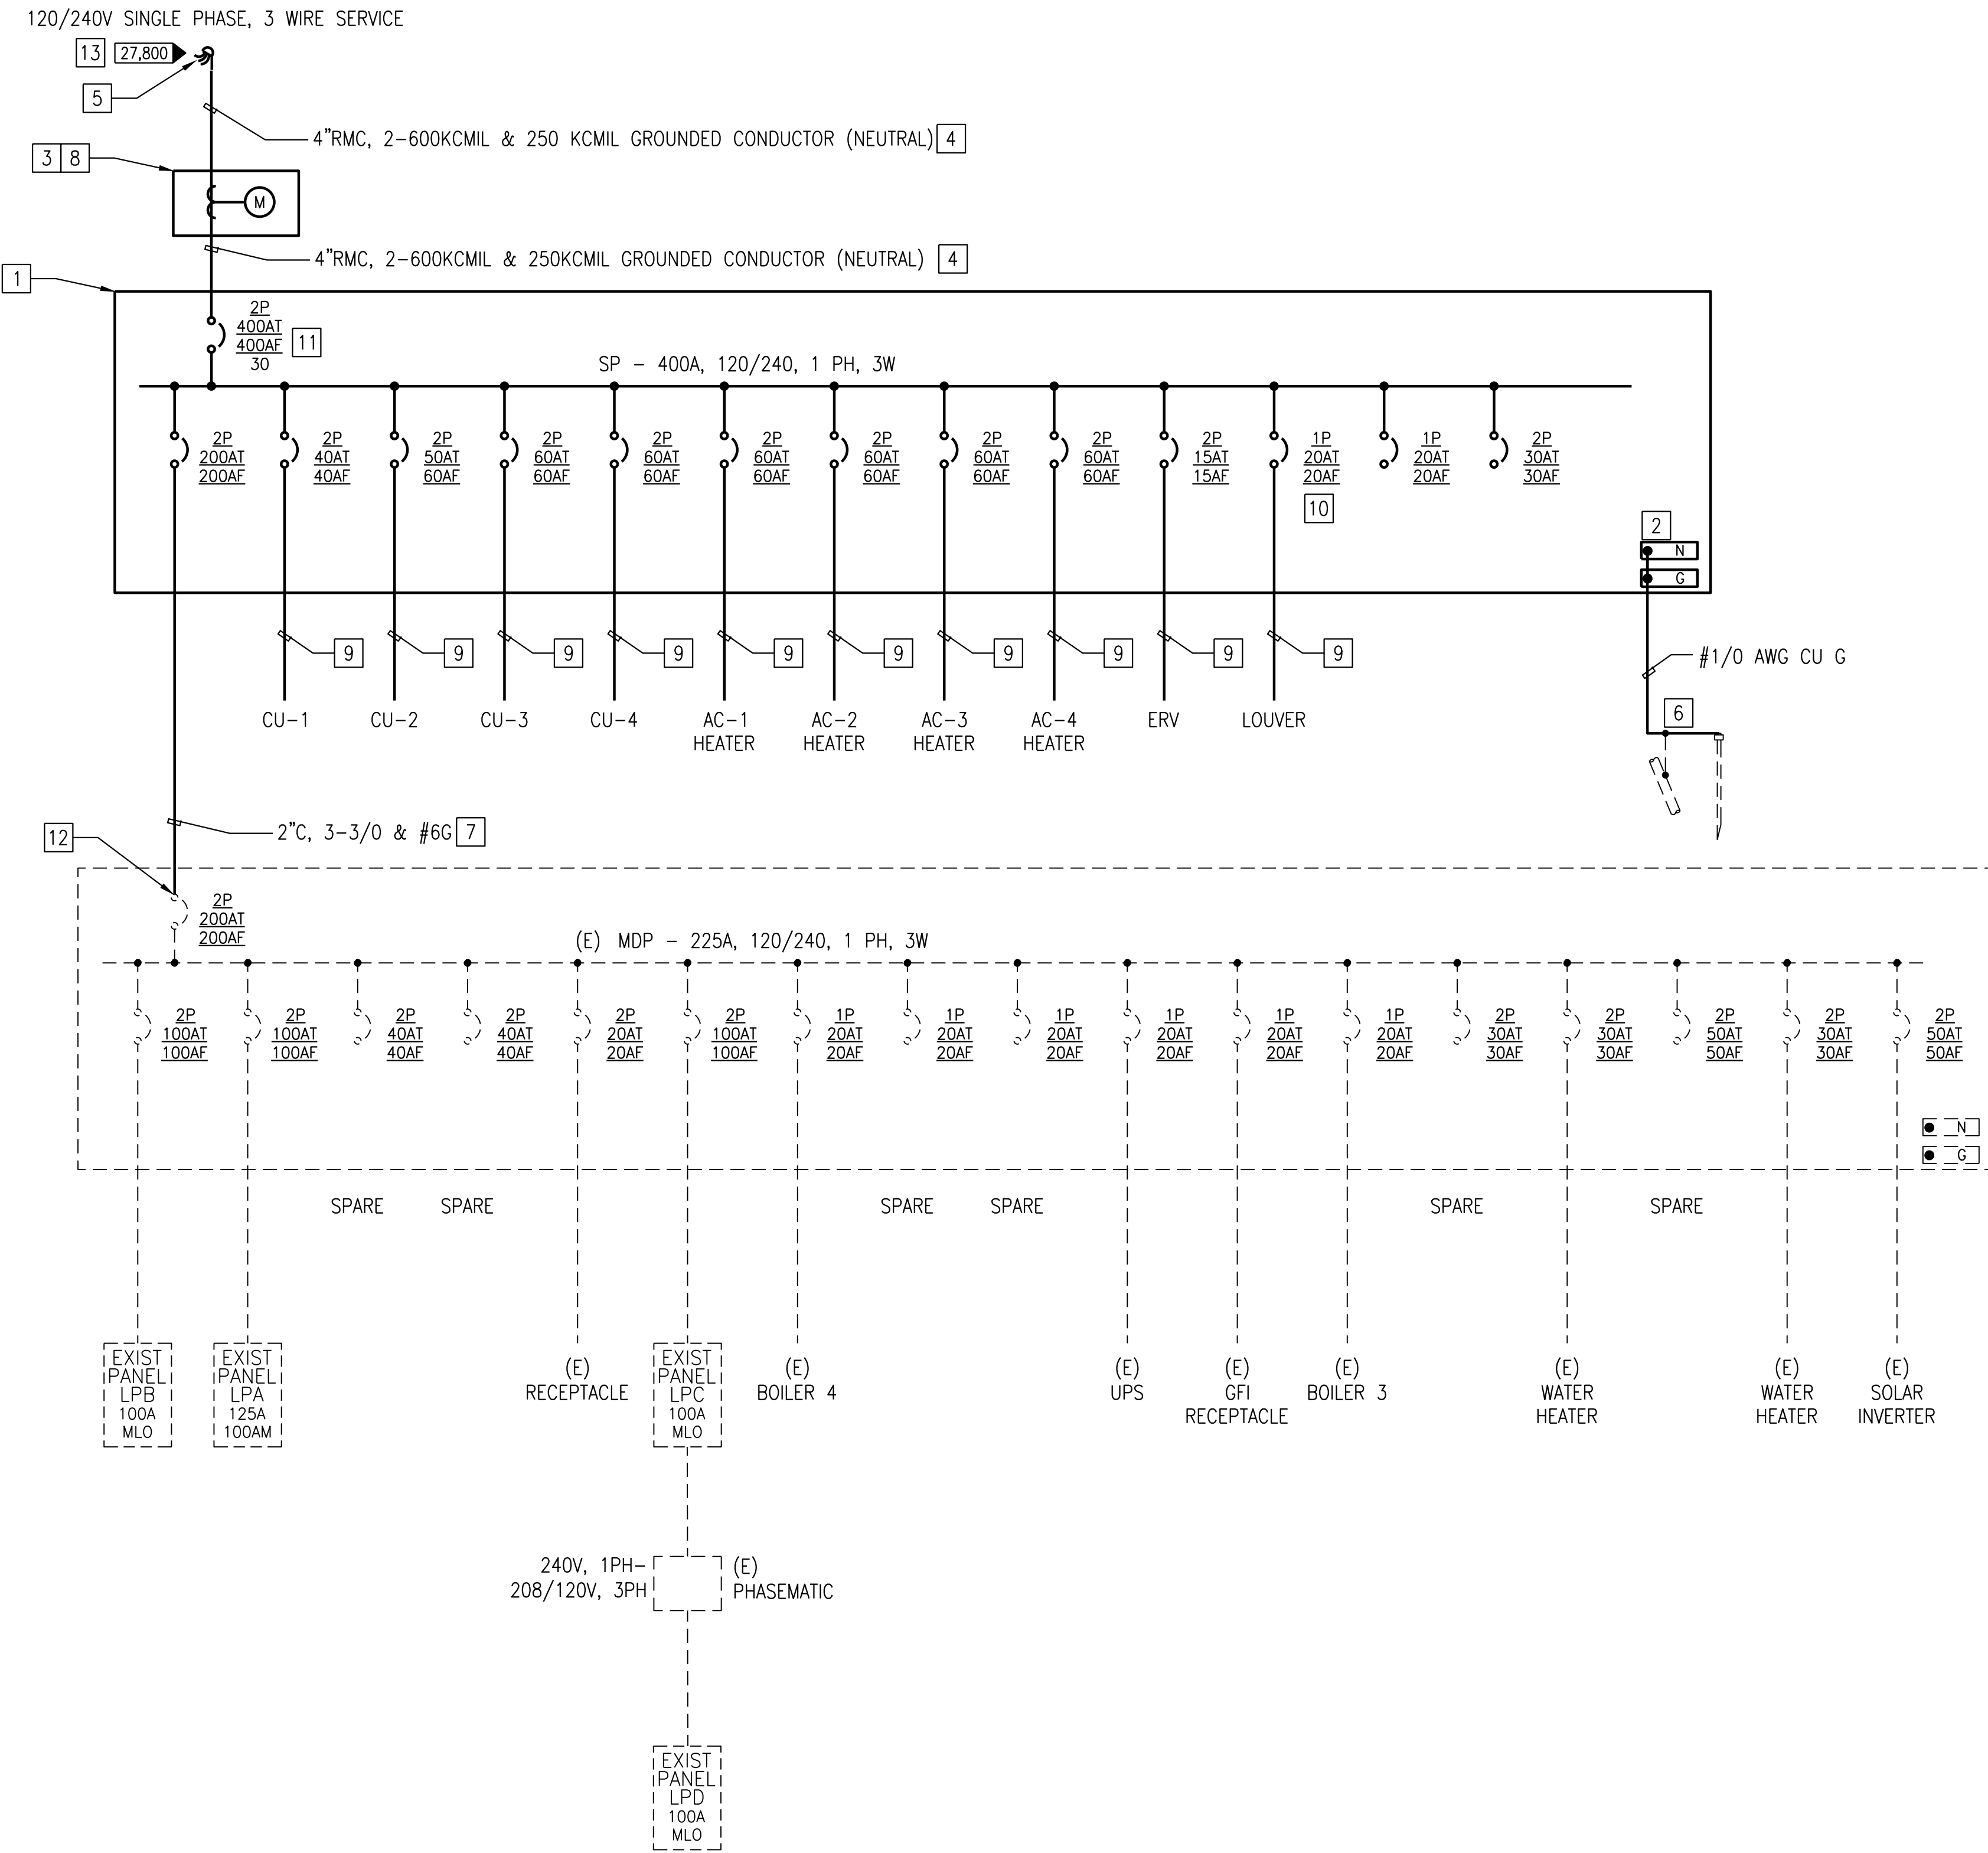

ELECTRICAL SINGLE-LINE DIAGRAM (NEW)

SCALE: NTS

PLAN NORTH



GENERAL SHEET NOTES

1. COORDINATION IS REQUIRED WITH RHODE ISLAND ENERGY.

KEYNOTES

- 1 PROVIDE PANEL AS SHOWN. ALL CIRCUIT BREAKERS ARE NOT SHOWN ON SINGLE-LINE FOR SIMPLICITY, REFER TO PANEL SCHEDULE ON E0.4 FOR CIRCUIT BREAKERS. PROVIDE PANEL WITH SURGE PROTECTIVE DEVICE. REFER TO E1.1 FOR PANEL LOCATION. PROVIDE PERMANENT PLAQUE OR DIRECTORY INDICATING SOURCES OF ENERGY AND STATING "CAUTION: MULTIPLE SOURCES OF POWER" PER NEC 705.10.
- 2 PROVIDE 1/0 AWG CU OR LARGER MAIN BONDING OR OTHER PERMITTED MEANS TO COMPLY WITH NEC 250.28.
- 3 PROVIDE METER ENCLOSURE PER RHODE ISLAND ENERGY REQUIREMENTS.
- 4 PROVIDE CONDUIT AND CONDUCTORS AS INDICATED. PROVIDE SERVICE ENTRANCE AND RISER PER NEC 230.50.
- 5 PROVIDE SERVICE HEAD PER NEC 230.54 AND PER RHODE ISLAND ENERGY'S REQUIREMENTS. COORDINATE NEW SERVICE WITH RHODE ISLAND ENERGY.
- 6 PROVIDE CONNECTION TO ALL PRESENT GROUNDING ELECTRODES DESCRIBED IN CEC 250.52. CONNECTION TO GROUND ROD MAY BE #6 AWG CU PER CEC 250.66(A).
- 7 PROVIDE CONDUIT AND CONDUCTORS AS INDICATED.
- 8 COORDINATE METER INSTALLATION WITH RHODE ISLAND ENERGY.
- 9 REFER TO E1.1 FOR FEEDER INFORMATION.
- 10 COORDINATE MOCF WITH LOUVER MANUFACTURER.
- 11 PROVIDE 100% RATED CIRCUIT BREAKER.
- 12 FEEDER TERMINATION IN MDP REQUIRES AN OUTAGE. COORDINATE OUTAGE WITH OWNER.
- 13 VALUE BASED ON ESB 750 MAXIMUM VALUE FOR THE SECONDARY OF A 100KVA TRANSFORMER. VALUE IS LIKELY MUCH LOWER. OBTAIN ACTUAL VALUE FROM RHODE ISLAND ENERGY; NOTIFY ENGINEER IF VALUE FROM RHODE ISLAND ENERGY IS HIGHER.



REV 1 - MECHANICAL EQUIPMENT	05MAR25
Revision:	Date:

CONSULTANTS
MEP ENGINEER: Andre Gill Engineering, LLC 40 Overlea Road North Smithfield, RI 02896 T: 401.441.3414 E: andregillengineering.com W: www.andregillengineering.com

STAMP

(1)Owner acknowledges that such Documents are not intended or represented to be suitable for use on the Project unless completed by AGE, or for use or reuse by Owner or others on extensions of the Project, on any other project, or for any other use or purpose, without written verification or adaptation by AGE; (2)any such use or reuse, or any modification of the Documents, without written verification, completion, or adaptation by AGE, as appropriate for the specific purpose intended, will be at Owner's sole risk and without liability or legal exposure to AGE or to its officers, directors, members, partners, agents, employees, and Consultants (3)Owner shall indemnify and hold harmless AGE and its officers, directors, members, partners, agents, employees, and Consultants from all claims, damages, losses, and expenses, including attorneys' fees, arising out of or resulting from any use, reuse, or modification of the Documents without written verification, completion, or adaptation by AGE; and (4) such limited license to Owner shall not create any rights in third parties.



Project Title: THE NARRAGANSETT BAY NATIONAL ESTUARINE RESEARCH RESERVE		Project Number 2407	
Location: FIELD STATION PHASE VI PRUDENCE ISLAND		Drawing Scale	
Drawing Title: ELECTRICAL SINGLE-LINE DIAGRAM (NEW)		Drawing Number E0.3	
Issue Date: 09/16/24	Approved By: AGE	Drawn By: AGE	Checked By: MTO

KEYNOTES

1 EXISTING MDP LOAD MUST BE LESS THAN 200A DUE TO OVERCURRENT PROTECTION. THEREFORE, NEW MDP LOAD MUST BE LESS THAN 105A SINCE EIGHT (8) MECHANICAL UNITS ARE BEING REMOVED WHICH DRAW APPROXIMATELY 95A (200-95=105).

SP

ROOM		VOLTS 240/120V 2P 3W		AIC 30,000			
MOUNTING FLUSH		BUS AMPS 400		MAIN BKR 400			
FED FROM UTILITY		NEUTRAL 100%		LUGS STANDARD			
NOTE							

CKT #	CKT BKR	CIRCUIT DESCRIPTION	LOAD KVA		CKT #	CKT BKR	CIRCUIT DESCRIPTION	LOAD KVA	
			A	B				A	B
1	200/2	PANEL MDP	12.6		2	20/2	SPACE	0	
3				12.6	4				0
5	40/2	CU-1	2.83		6	60/2	CU-3	3	
7				2.83	8				3
9	50/2	CU-2	2.95		10	60/2	CU-4	3	
11				2.95	12				3
13	60/2	AC-1 HEATER	5		14	20/2	SPACE	0	
15				5	16				0
17	60/2	AC-2.1 HEATER	5		18	20/2	SPACE	0	
19				5	20				0
21	60/2	AC-3.1 HEATER	5		22	20/2	SPACE	0	
23				5	24				0
25	60/2	AC-4.1 HEATER	5		26	20/2	SPACE	0	
27				5	28				0
29	15/2	ERV	0.816		30	15/1	LOUVER	0.3	
31				0.816	32	20/1	SPACE	0	
33	20/1	SPACE	0		34	20/1	SPACE	0	
35	20/1	SPACE		0	36	20/1	SPACE		0
37	20/1	SPACE	0		38	20/1	SPACE	0	
39	20/1	SPACE		0	40	20/1	SPACE		0
41	20/1	SPACE	0		42	20/1	SPACE	0	
					TOTAL CONNECTED KVA BY PHASE			45.5	45.2

CONN KVA		CALC KVA		CONN KVA		CALC KVA	
LARGEST MOTOR	4.56	1.14	(25%)	NONCONTINUOUS	25.3	25.3	(100%)
MOTORS	0.3	0.3	(100%)	HEATING	65.1	65.1	(100%)
				COOLING	25.1	0	(0%)
				TOTAL LOAD	91.8		
				BALANCED LOAD	383 A		

PANEL SCHEDULE

SCALE: NTS

PLAN NORTH



REV 1 - MECHANICAL EQUIPMENT	05MAR25
Revision:	Date:

CONSULTANTS
MEP ENGINEER: Andre Gill Engineering, LLC 40 Overlea Road North Smithfield, RI 02896 T: 401.441.3414 E: andregillengineering.com W: www.andregillengineering.com

STAMP
MICHAEL TERENCE O'BRIEN No. 12511 REGISTERED PROFESSIONAL ENGINEER (ELECTRICAL) Michael O'Brien

(1)Owner acknowledges that such Documents are not intended or represented to be suitable for use on the Project unless completed by AGE, or for use or reuse by Owner or others on extensions of the Project, on any other project, or for any other use or purpose, without written verification or adaptation by AGE; (2)any such use or reuse, or any modification of the Documents, without written verification, completion, or adaptation by AGE, as appropriate for the specific purpose intended, will be at Owner's sole risk and without liability or legal exposure to AGE or to its officers, directors, members, partners, agents, employees, and Consultants (3)Owner shall indemnify and hold harmless AGE and its officers, directors, members, partners, agents, employees, and Consultants from all claims, damages, losses, and expenses, including attorneys' fees, arising out of or resulting from any use, reuse, or modification of the Documents without written verification, completion, or adaptation by AGE; and (4) such limited license to Owner shall not create any rights in third parties.



Project Title: THE NARRAGANSETT BAY NATIONAL ESTUARINE RESEARCH RESERVE		Project Number 2407	
Location: FIELD STATION PHASE VI PRUDENCE ISLAND		Drawing Scale	
Drawing Title: PANEL SCHEDULE		Drawing Number E0.4	
Issue Date: 09/16/24	Approved By: AGE	Drawn By: AGE	Checked By: MTO

A

B

C


D

E

9/25/2024 5:27:29 PM


KEYNOTES

1 DEMOLISH DISCONNECT FOR HVAC EQUIPMENT AND CIRCUITING INCLUDING CONDUIT BACK TO SOURCE PANEL.

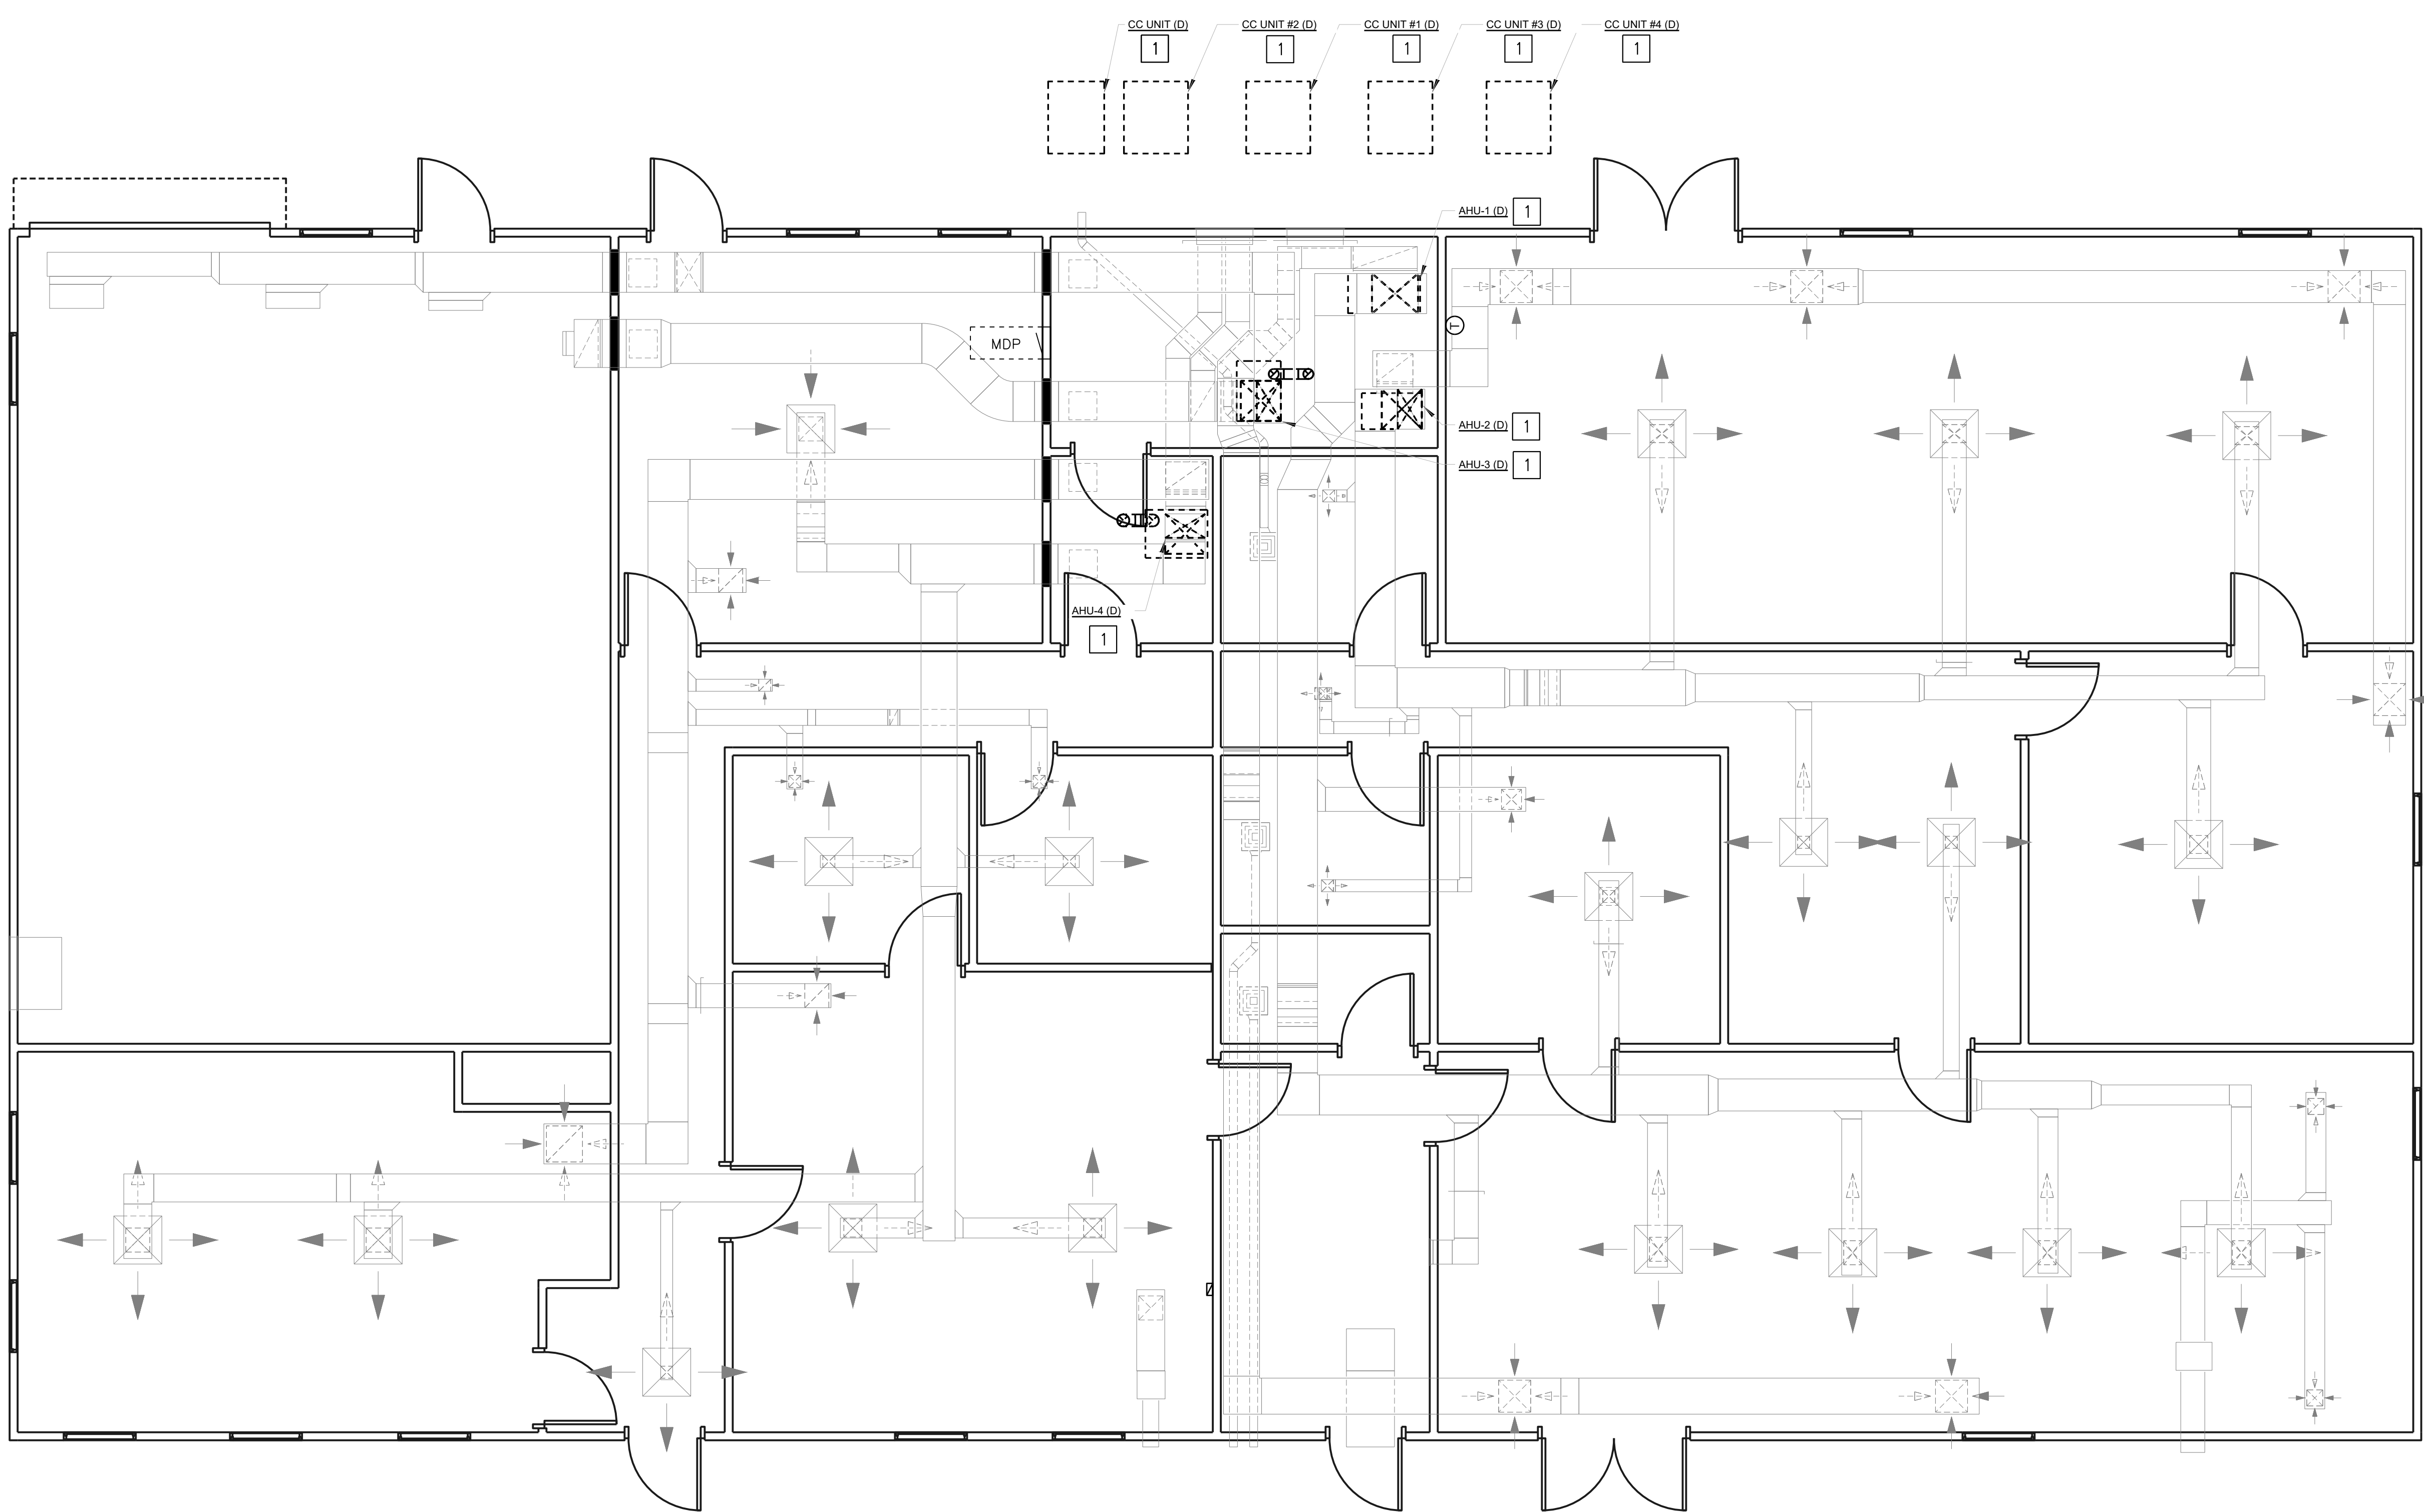

ELECTRICAL DEMOLITION PLAN

SCALE: 1/4" = 1'-0"

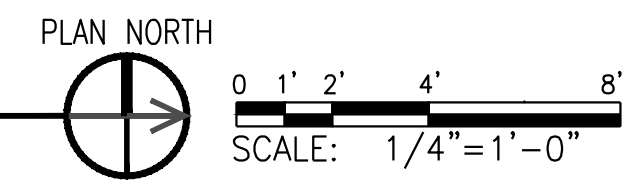

REV 1 - MECHANICAL EQUIPMENT	05MAR25
Revision:	Date:

CONSULTANTS
MEP ENGINEER: Andre Gill Engineering, LLC 40 Overlea Road North Smithfield, RI 02896 T: 401.441.3414 E: andregillengineering.com W: www.andregillengineering.com

STAMP

(1)Owner acknowledges that such Documents are not intended or represented to be suitable for use on the Project unless completed by AGE, or for use or reuse by Owner or others on extensions of the Project, on any other project, or for any other use or purpose, without written verification or adaptation by AGE; (2)any such use or reuse, or any modification of the Documents, without written verification, completion, or adaptation by AGE, as appropriate for the specific purpose intended, will be at Owner's sole risk and without liability or legal exposure to AGE or to its officers, directors, members, partners, agents, employees, and Consultants (3)Owner shall indemnify and hold harmless AGE and its officers, directors, members, partners, agents, employees, and Consultants from all claims, damages, losses, and expenses, including attorneys' fees, arising out of or resulting from any use, reuse, or modification of the Documents without written verification, completion, or adaptation by AGE; and (4) such limited license to Owner shall not create any rights in third parties.



Project Title: THE NARRAGANSETT BAY NATIONAL ESTUARINE RESEARCH RESERVE		Project Number 2407
Location: FIELD STATION PHASE VI PRUDENCE ISLAND		Drawing Scale
Drawing Title: ELECTRICAL DEMOLITION PLAN		Drawing Number E1.0
Issue Date: 09/16/24	Approved By: AGE	Drawn By: AGE
		Checked By: MTO

A


B

C

D

E

8/25/2024 5:27:28 PM

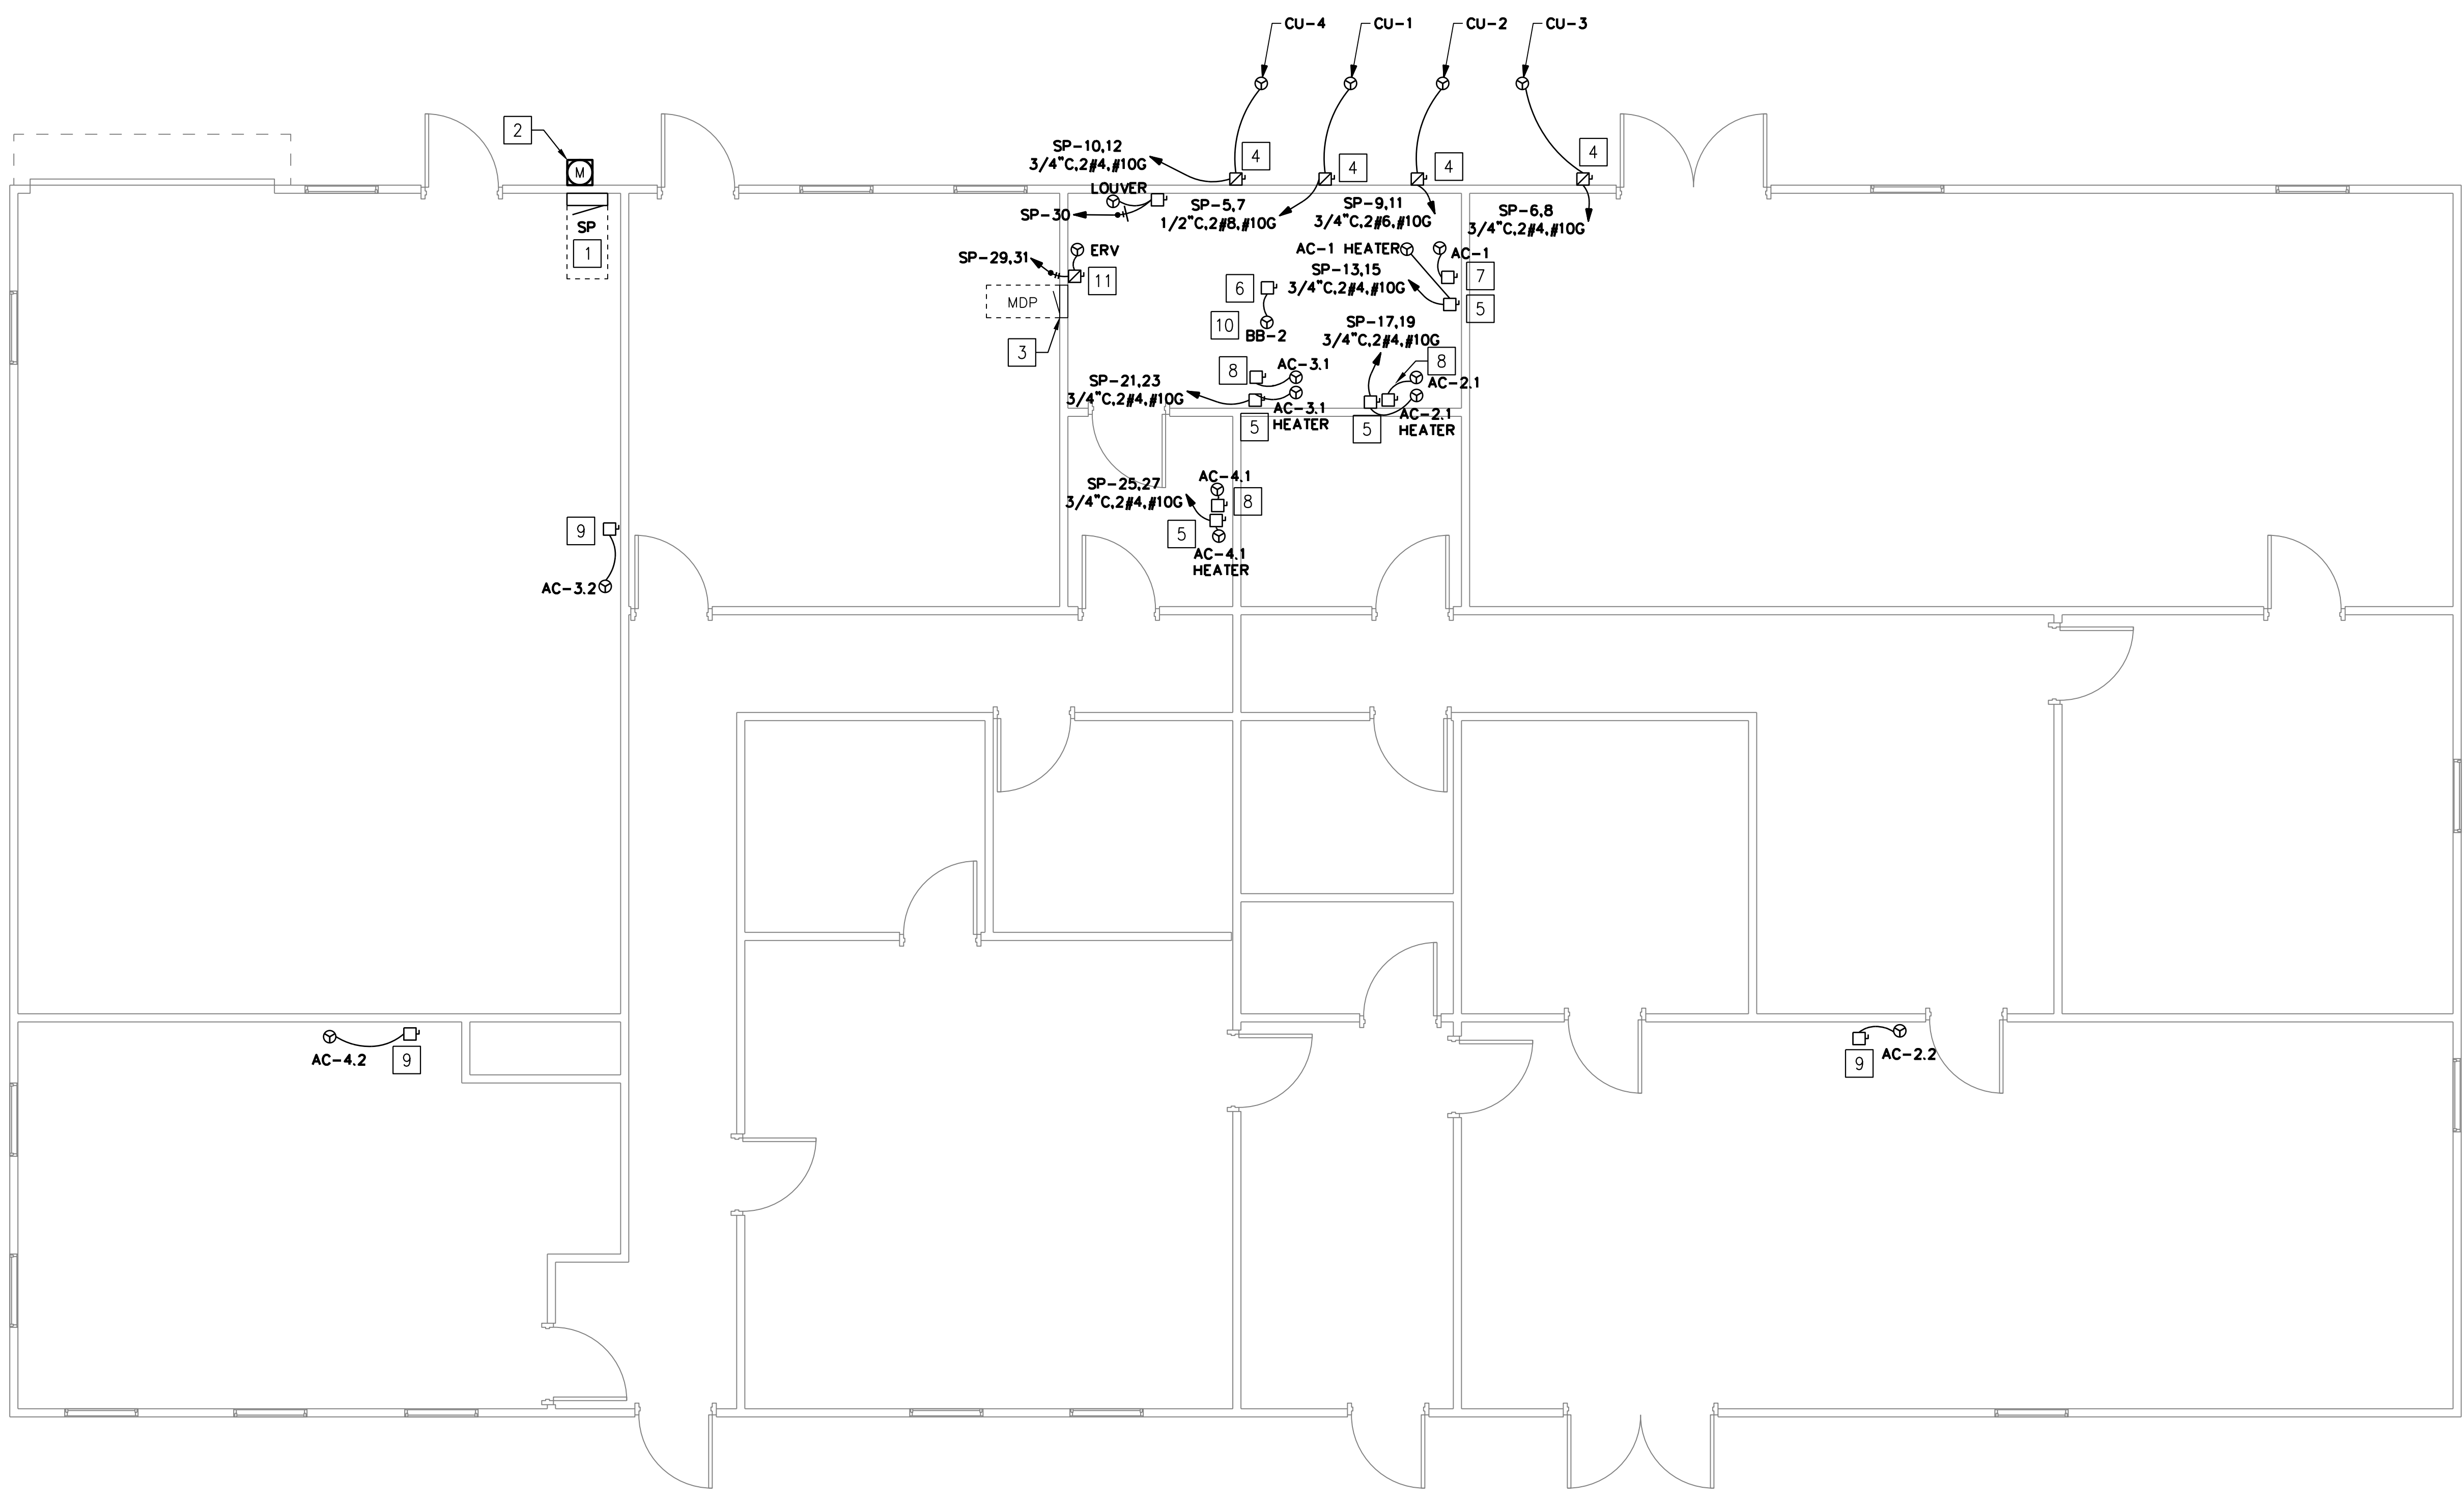

GENERAL SHEET NOTES


1. MINIMUM CONDUIT SIZE IS 3/4".
2. PROVIDE FINAL CONNECTIONS TO MOTORS WITH FLEXIBLE CONDUIT.
3. REFER TO MECHANICAL DRAWINGS FOR MORE PRECISE MECHANICAL EQUIPMENT LOCATIONS.

KEYNOTES

- 1 PROVIDE PANEL PER E0.3 AND E0.4. MAINTAIN CLEARANCE AS SHOWN.
- 2 PROVIDE METER ENCLOSURE AND RISER AND COORDINATE NEW SERVICE WITH RHODE ISLAND ENERGY PER E0.3.
- 3 PROVIDE NEW FEEDER TO MDP AND DEMOLISH EXISTING SERVICE TO MDP PER E0.3 AND E0.2.
- 4 PROVIDE TWO POLE, 60A, NEMA 3R HEAVY DUTY DISCONNECT SWITCH. FUSE PER MANUFACTURER'S RECOMMENDATIONS.
- 5 PROVIDE TWO POLE, 60A, HEAVY DUTY DISCONNECT SWITCH IF EQUIPMENT DOES NOT HAVE LOCAL DISCONNECT IN COMPLIANCE WITH NEC 424.19(B).
- 6 PROVIDE TWO POLE, 30A DISCONNECT SWITCH FOR BRANCH BOX. PROVIDE WIRING TO CU-2 IN 1/2\"/>


ELECTRICAL POWER PLAN

SCALE: 1/4" = 1'-0"

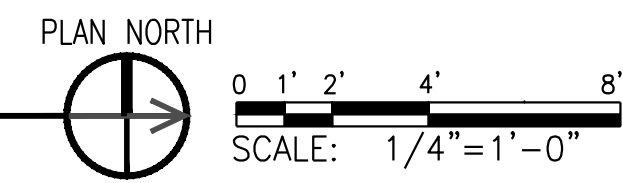

REV 1 - MECHANICAL EQUIPMENT	05MAR25
Revision:	Date:

CONSULTANTS
MEP ENGINEER: Andre Gill Engineering, LLC 40 Overlea Road North Smithfield, RI 02896 T: 401.441.3414 E: andregillengineering.com W: www.andregillengineering.com

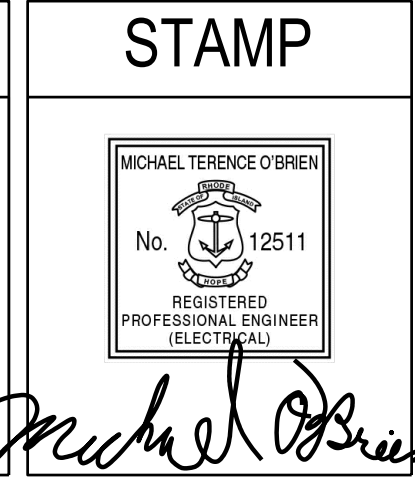

(1)Owner acknowledges that such Documents are not intended or represented to be suitable for use on the Project unless completed by AGE, or for use or reuse by Owner or others on extensions of the Project, on any other project, or for any other use or purpose, without written verification or adaptation by AGE; (2)any such use or reuse, or any modification of the Documents, without written verification, completion, or adaptation by AGE, as appropriate for the specific purpose intended, will be at Owner's sole risk and without liability or legal exposure to AGE or to its officers, directors, members, partners, agents, employees, and Consultants (3)Owner shall indemnify and hold harmless AGE and its officers, directors, members, partners, agents, employees, and Consultants from all claims, damages, losses, and expenses, including attorneys' fees, arising out of or resulting from any use, reuse, or modification of the Documents without written verification, completion, or adaptation by AGE; and (4) such limited license to Owner shall not create any rights in third parties.



Project Title: THE NARRAGANSETT BAY NATIONAL ESTUARINE RESEARCH RESERVE		Project Number 2407
Location: FIELD STATION PHASE VI PRUDENCE ISLAND		Drawing Scale
Drawing Title: ELECTRICAL POWER PLAN		Drawing Number E1.1
Issue Date: 09/16/24	Approved By: AGE	Drawn By: AGE
		Checked By: MTO